
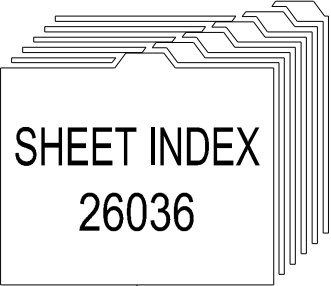



SAFE LOCAL ROADS AND STREET PROGRAM

COMPACT ROUNDABOUT - KEOGH STREET & POTTON AVENUE

CN0000

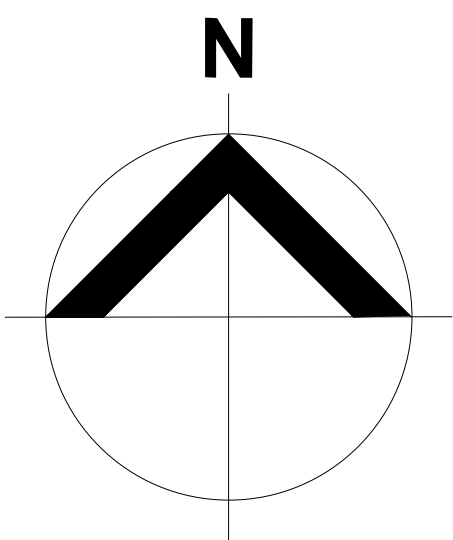

PLAN NUMBER	DESCRIPTION
26036-01	TITLE SHEET AND SITE PLAN [B]
26036-02	NOTES [B]
26036-03	TYPICAL SECTION AND PAVEMENT DETAILS [B]
26036-04	GENERAL ARRANGEMENT AND SPEED CUSHION SETOUT [B]
26036-05	KERB HORIZONTAL SETOUT INFORMATION [B]
26036-06	LONGSECTIONS - KERB_SE & KERB_NE [B]
26036-07	LONGSECTIONS - KERB_SW, KERB_NW, KERB_CNTR & FOOTPATH [B]
26036-08	LONGSECTIONS - MCP0 AND MCK0 [B]
26036-09	SIGNS AND LINEMARKING ARRANGEMENT [B]
26036-10	ANNOTATED CROSS SECTIONS - MCK0 (1 OF 2) [B]
26036-11	ANNOTATED CROSS SECTIONS - MCK0 (2 OF 2) [B]
26036-12	ANNOTATED CROSS SECTIONS - MCP0 (1 OF 2) [B]
26036-13	ANNOTATED CROSS SECTIONS - MCP0 (2 OF 2) [B]

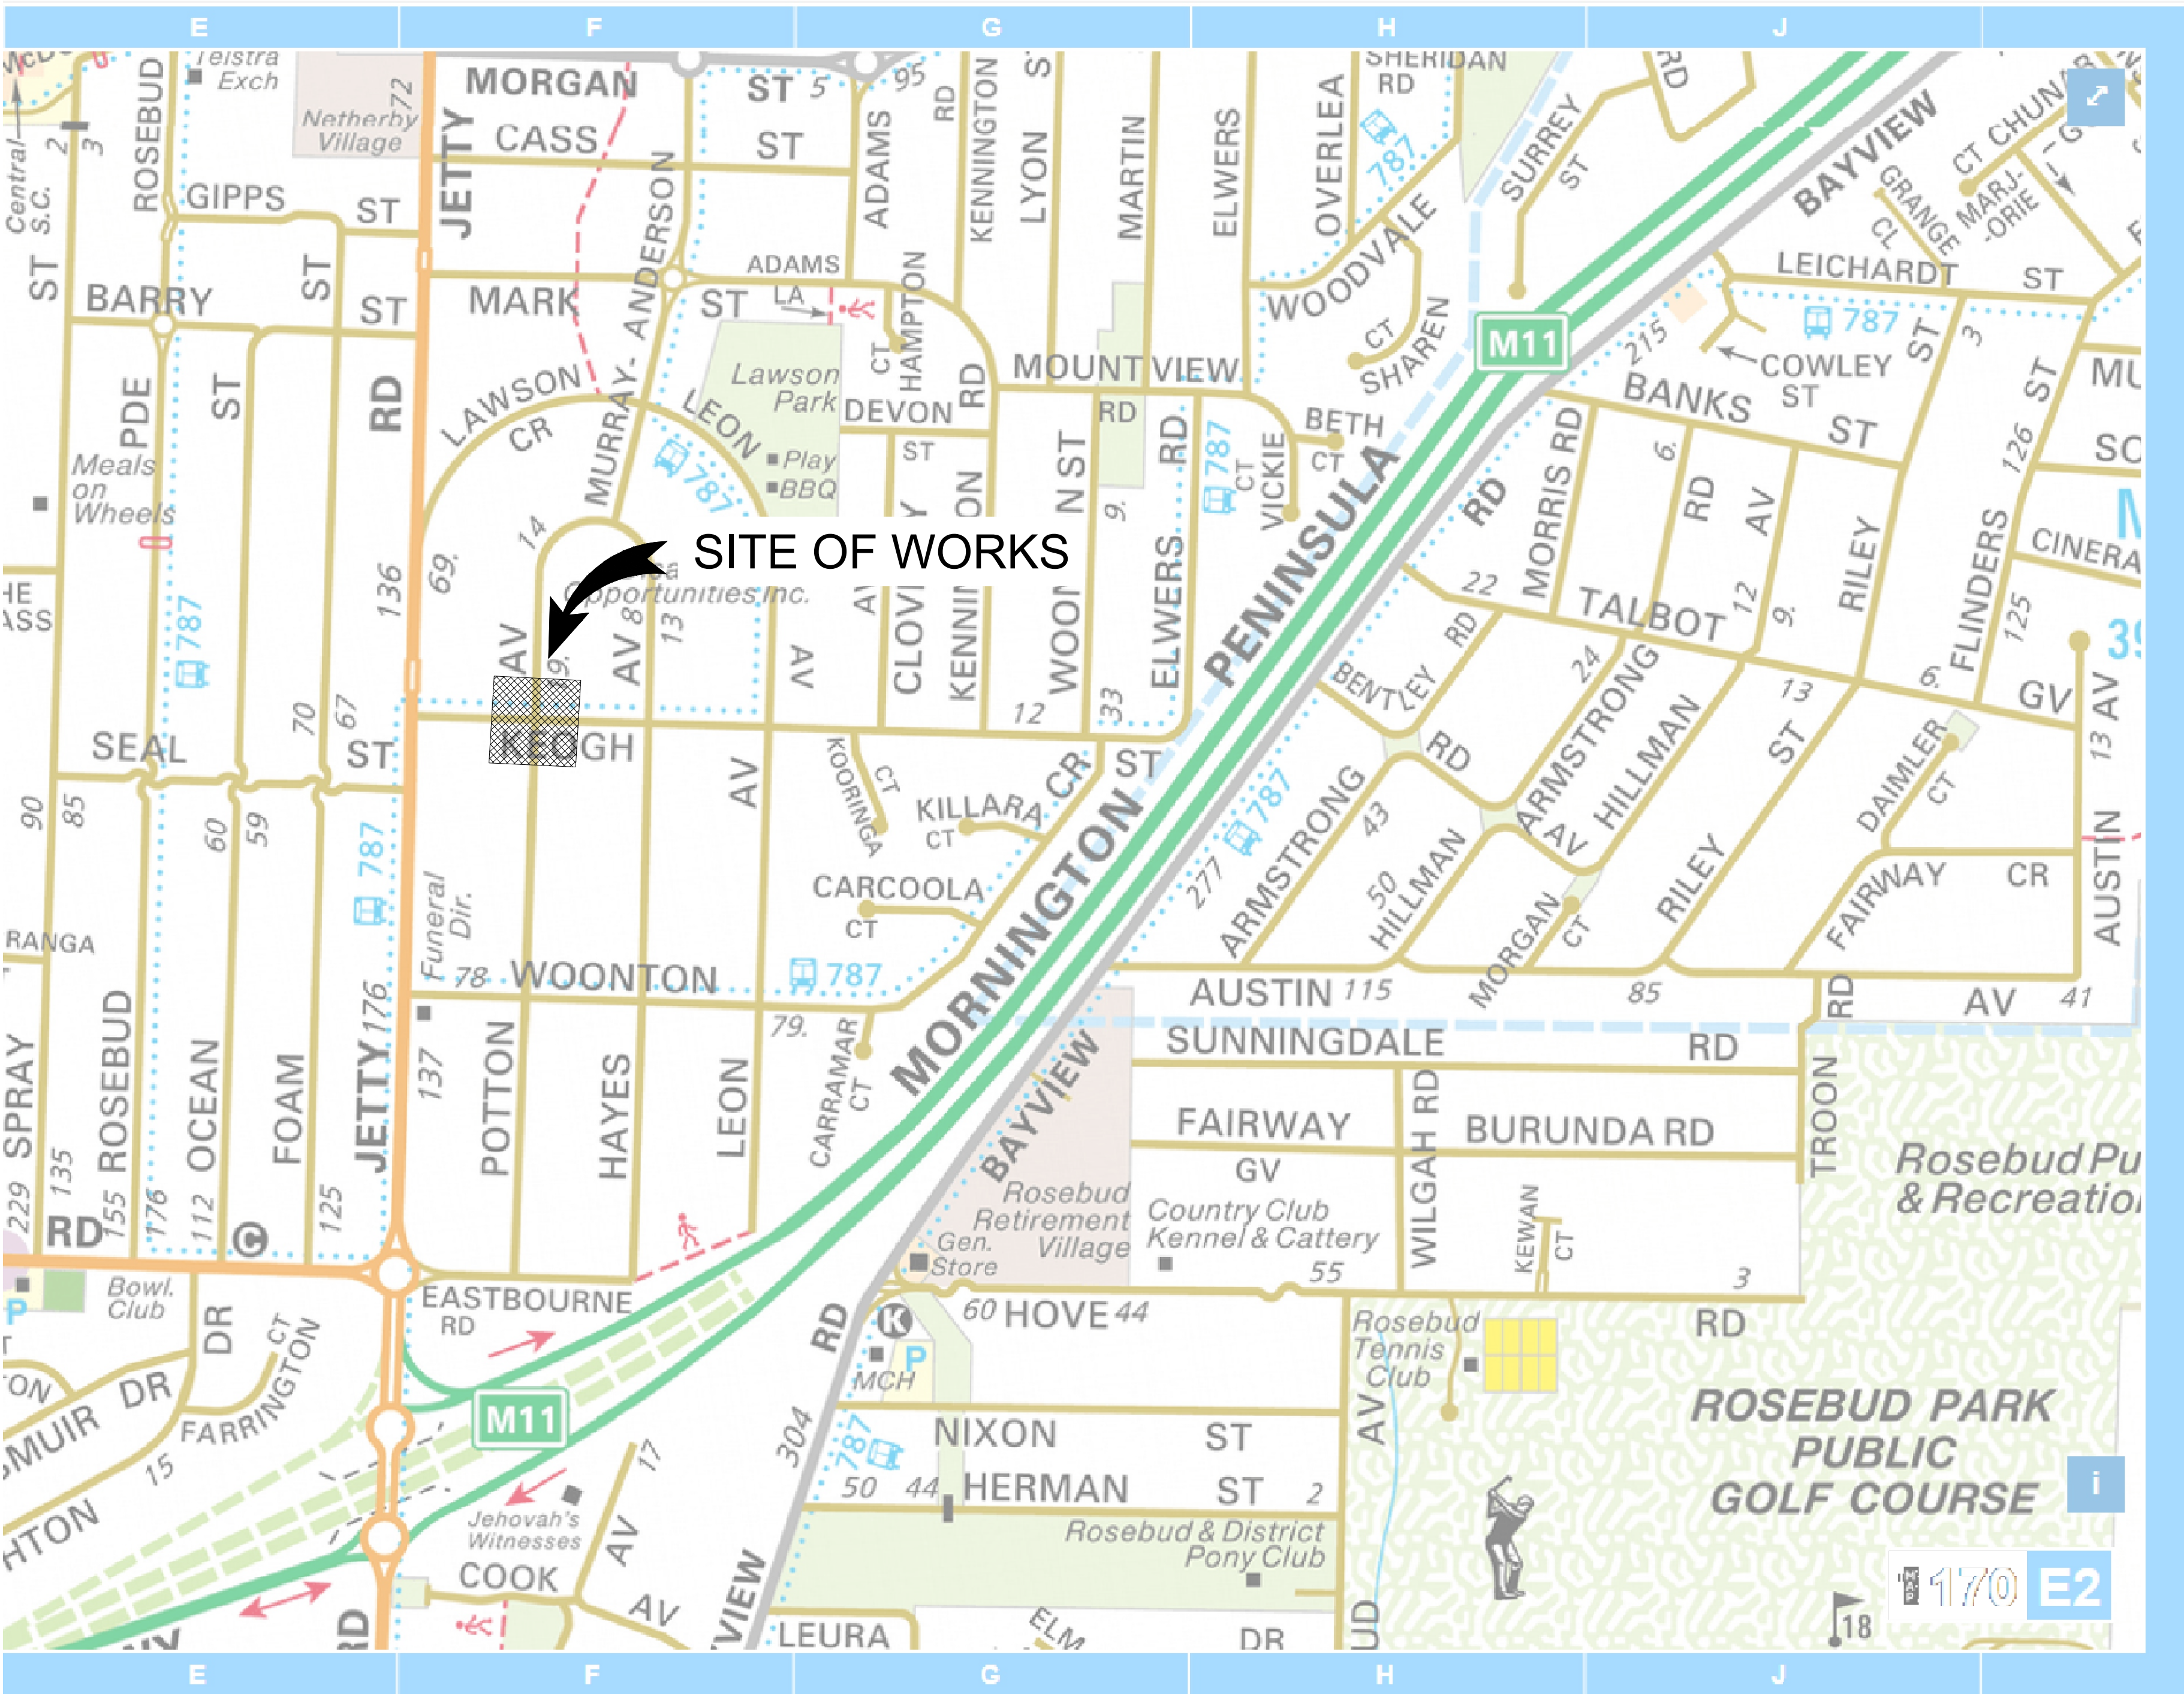

LOCALITY PLAN

NOT TO SCALE

TENDER

LEGEND					
	TELSTRA POLE		FIRE HYDRANT		EX UNDERGROUND ELECTRICITY CABLE
	TELSTRA PIT		WATER STOP VALVE		EX OVERHEAD POWER CABLE
	PHONE BOX		GAS VALVE		PROPOSED WATER MAIN
	POWER POLE		SEWER MANHOLE		PROPOSED GAS MAIN
	LIGHT POLE		EX WATER MAIN		PROPOSED U/G TELSTRA CABLE
	LANTERN		EX GAS MAIN		PROPOSED SEWER MAIN
	UNDERGROUND POWER PIT		EX U/GROUND TELSTRA CABLE		PROPOSED U/G ELECTRICITY CABLE
	FIRE PLUG		EX SEWER MAIN		PERMANENT SURVEY MARK
			PROPOSED KERB AND CHANNEL		EXISTING KERB AND CHANNEL
			TREE TO BE REMOVED		PROPOSED DRAINAGE
			EXISTING DRAINAGE		PIT NUMBER
			PROPOSED HOUSE DRAIN		

REGISTERED ENGINEERS DETAILS	
NAME:	Michael Robins
SIGNATURE:	
ENG.REG.:	0008852
COMPANY:	Mornington Peninsula Shire

B	TENDER ISSUE	MR	AW	MR	13/07/26
A	ISSUED FOR REVIEW				
No	DRAWING REVISION DETAILS	DES	CHKD	APPD	DATE



SAFE LOCAL ROADS AND STREET PROGRAM

ROSEBUD


KEOGH STREET & POTTON AVENUE

TITLE SHEET AND SITE PLAN


DATUM:	AHD
PROJECTION:	55/2020
DATE OF PLAN:	7/13/2026
SCALE AT A1:	NTS
SHEET No. 01 OF 13	
PLAN REF No.	REV
26036-01	B

GENERAL:


- 1
- 2
- 3
- 1492
- 14

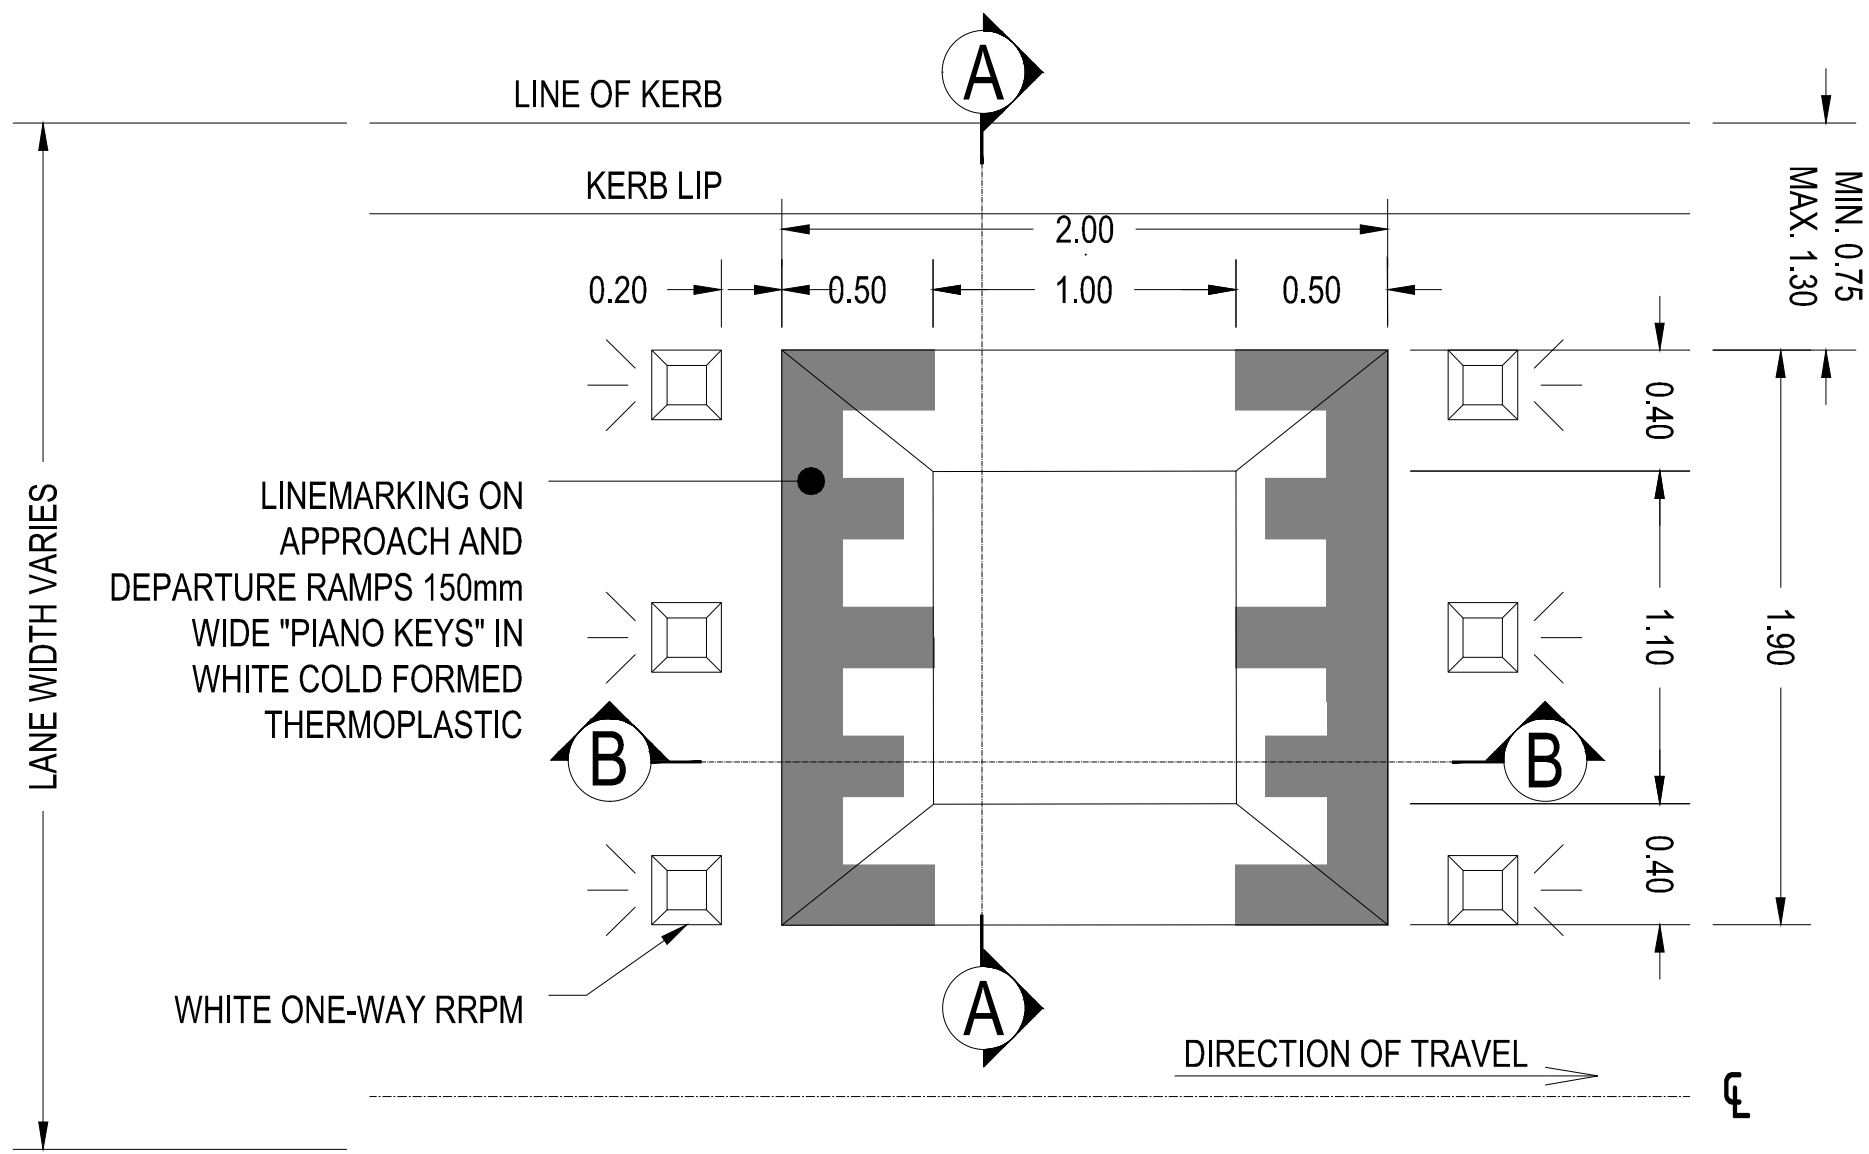

ASPHALT SPEED CUSHION
N.T.S.

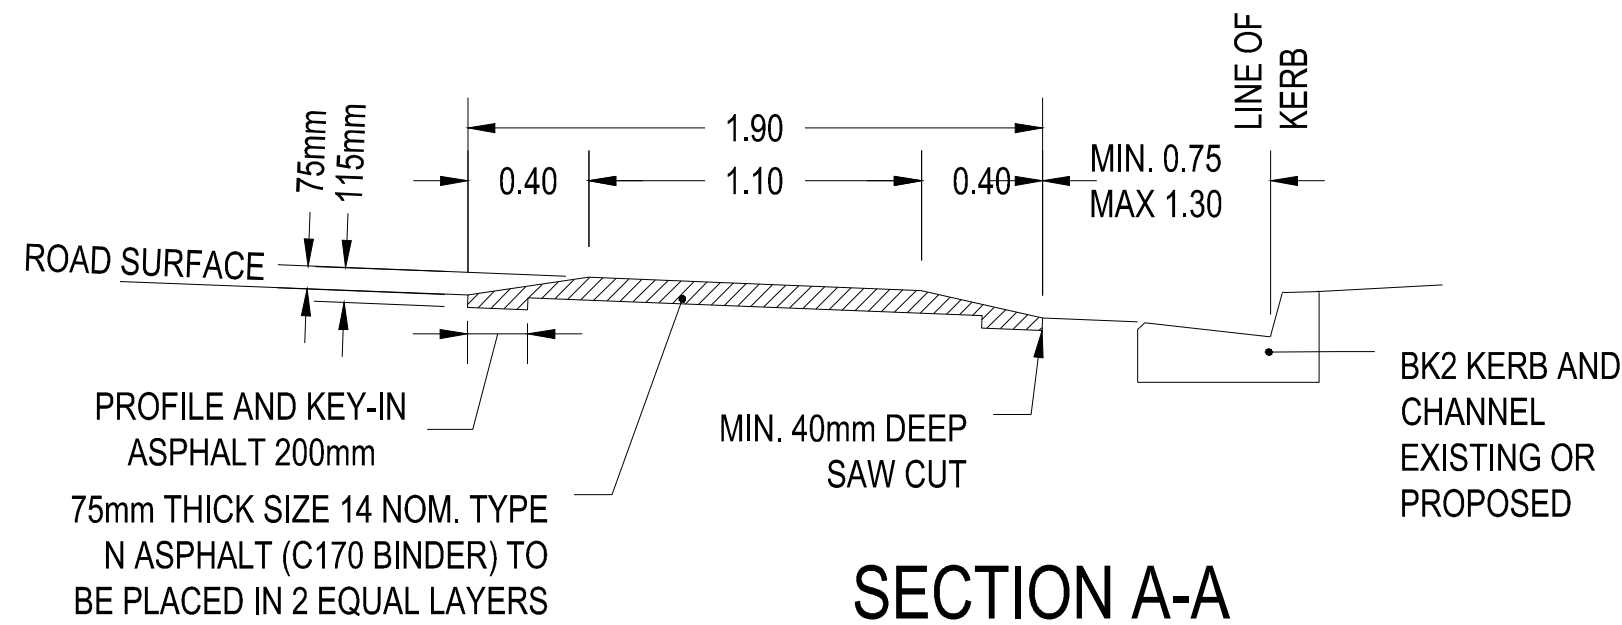

SECTION A-A
N.T.S.

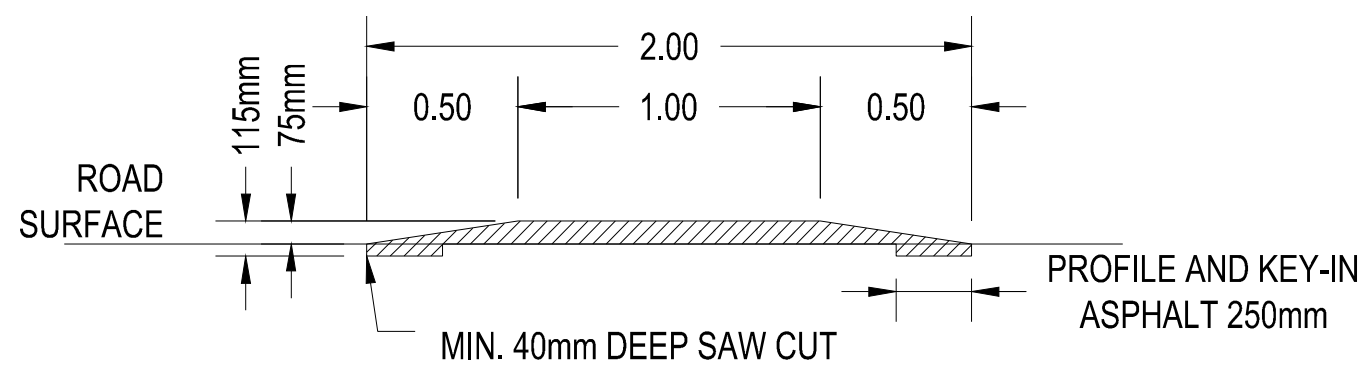


SECTION B-B
N.T.S.

ASPHALT RAISED CUSHION		
PAVEMENT LAYER	LAYER THICKNESS (mm)	MATERIAL
CUSHION	75	SIZE 14 TYPE N ASPHALT (CL170) PLACED IN 2 EQUAL LAYERS
WEARING COURSE	100	SIZE TYPE N ASPHALT (CL170) - AS PER ASPHALT RESHEET
EXISTING		IN SITU
TOTAL DEPTH	175	


ROUNDBABOUT ISLAND		
PAVEMENT LAYER	LAYER THICKNESS (mm)	MATERIAL
WEARING COURSE	150	N25 CONCRETE WITH SL72 MESH CENTRALLY PLACED
BASE	50	20mm CLASS 3 F.C.R. MECHANICALLY COMPACTED
EXISTING		IN SITU
TOTAL DEPTH	200	

CONCRETE FOOTPATH		
PAVEMENT LAYER	LAYER THICKNESS (mm)	MATERIAL
WEARING COURSE	125	N25 CONCRETE (SL72 MESH. 50mm TOP COVER WHERE SHOWN)
BASE	50	20mm CLASS 3 F.C.R. MECHANICALLY COMPACTED
EXISTING		
TOTAL DEPTH	175	


ASPHALT RESHEET		
PAVEMENT LAYER	LAYER THICKNESS (mm)	MATERIAL
MILL/REMOVE EXISTING	100 (TYP)	REMOVAL OF EXISTING WEARING COURSE
WEARING COURSE	40	SIZE 10 TYPE N ASPHALT (CL170)
TACK COAT	-	CRS BITUMEN EMULSION @ 0.2 - 0.3L/m ²
BASE COURSE	60	SIZE 14 TYPE N ASPHALT (CL170)
PRIMERSEAL	-	7mm BITUMEN EMULSION (BITUMEN CONTENT < 60%) @ 0.9L/m ²
EXISTING	-	IN SITU - REMOVE AND REPLACE UNSUITABLE MATERIAL AS DIRECTED BY SUPERINTENDENT.
TOTAL DEPTH	100	

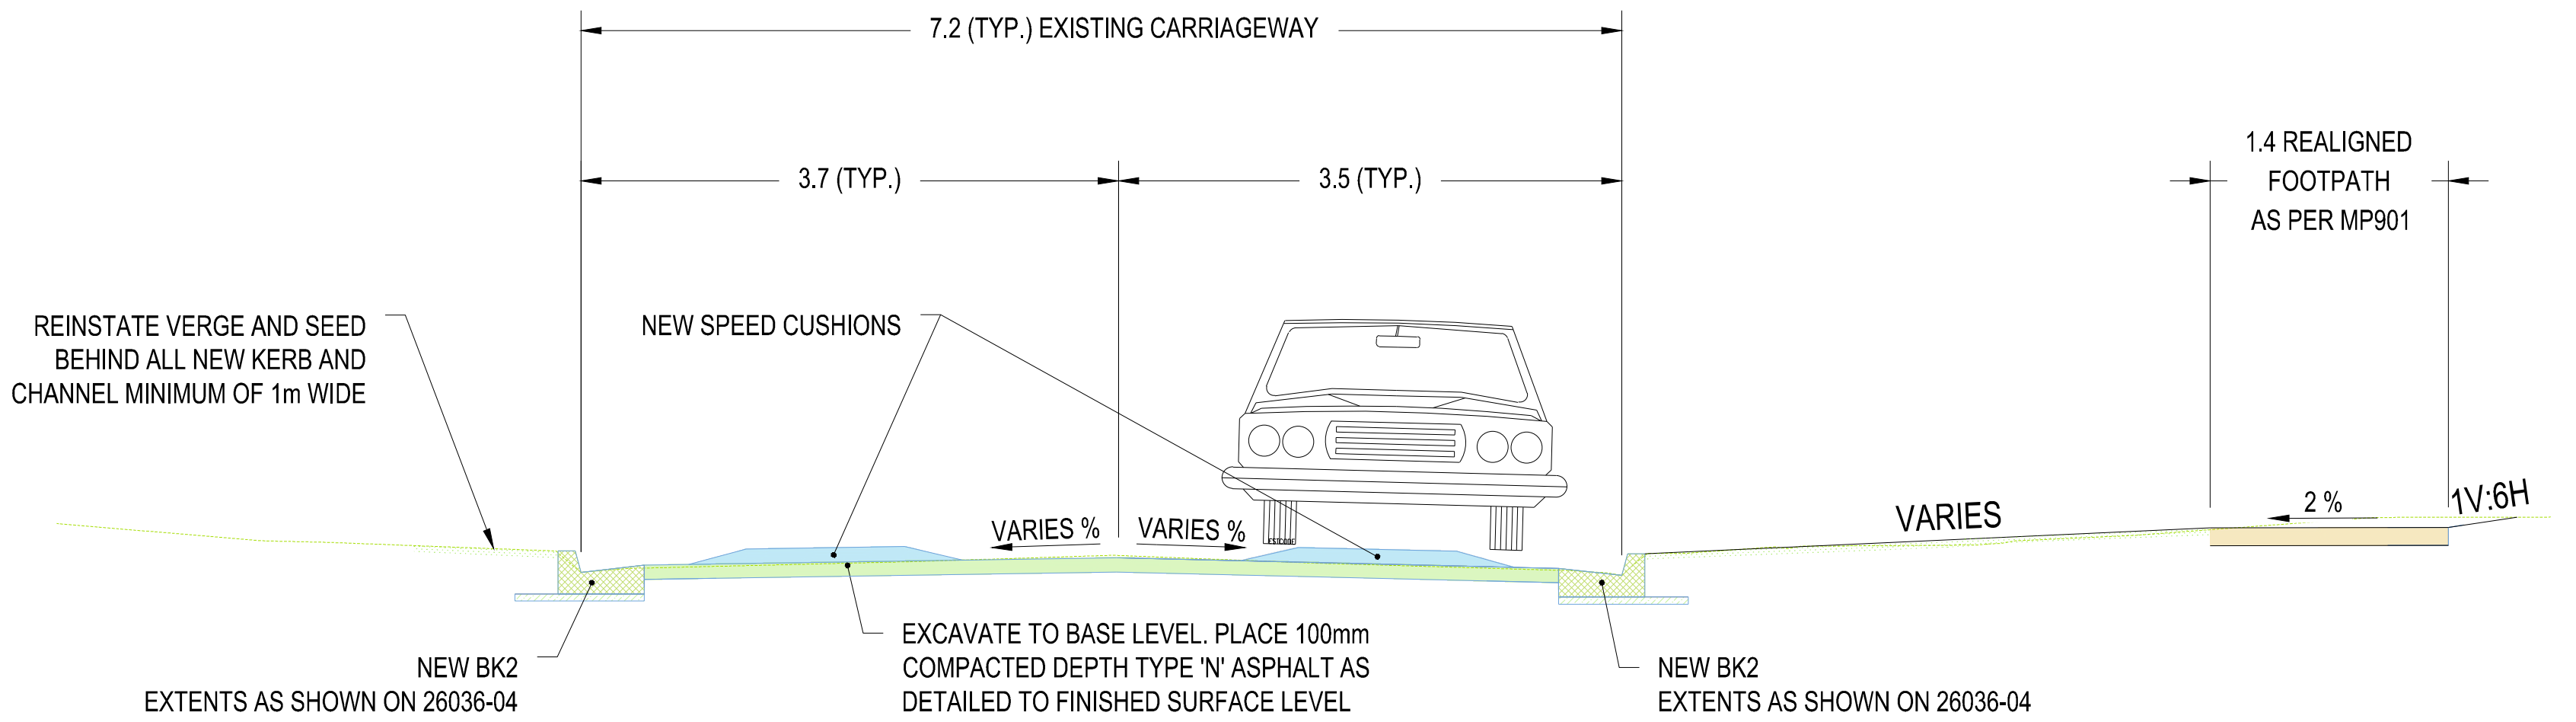


TYPICAL SECTION - ROUNDBABOUT APPROACH
SCALE 1:40

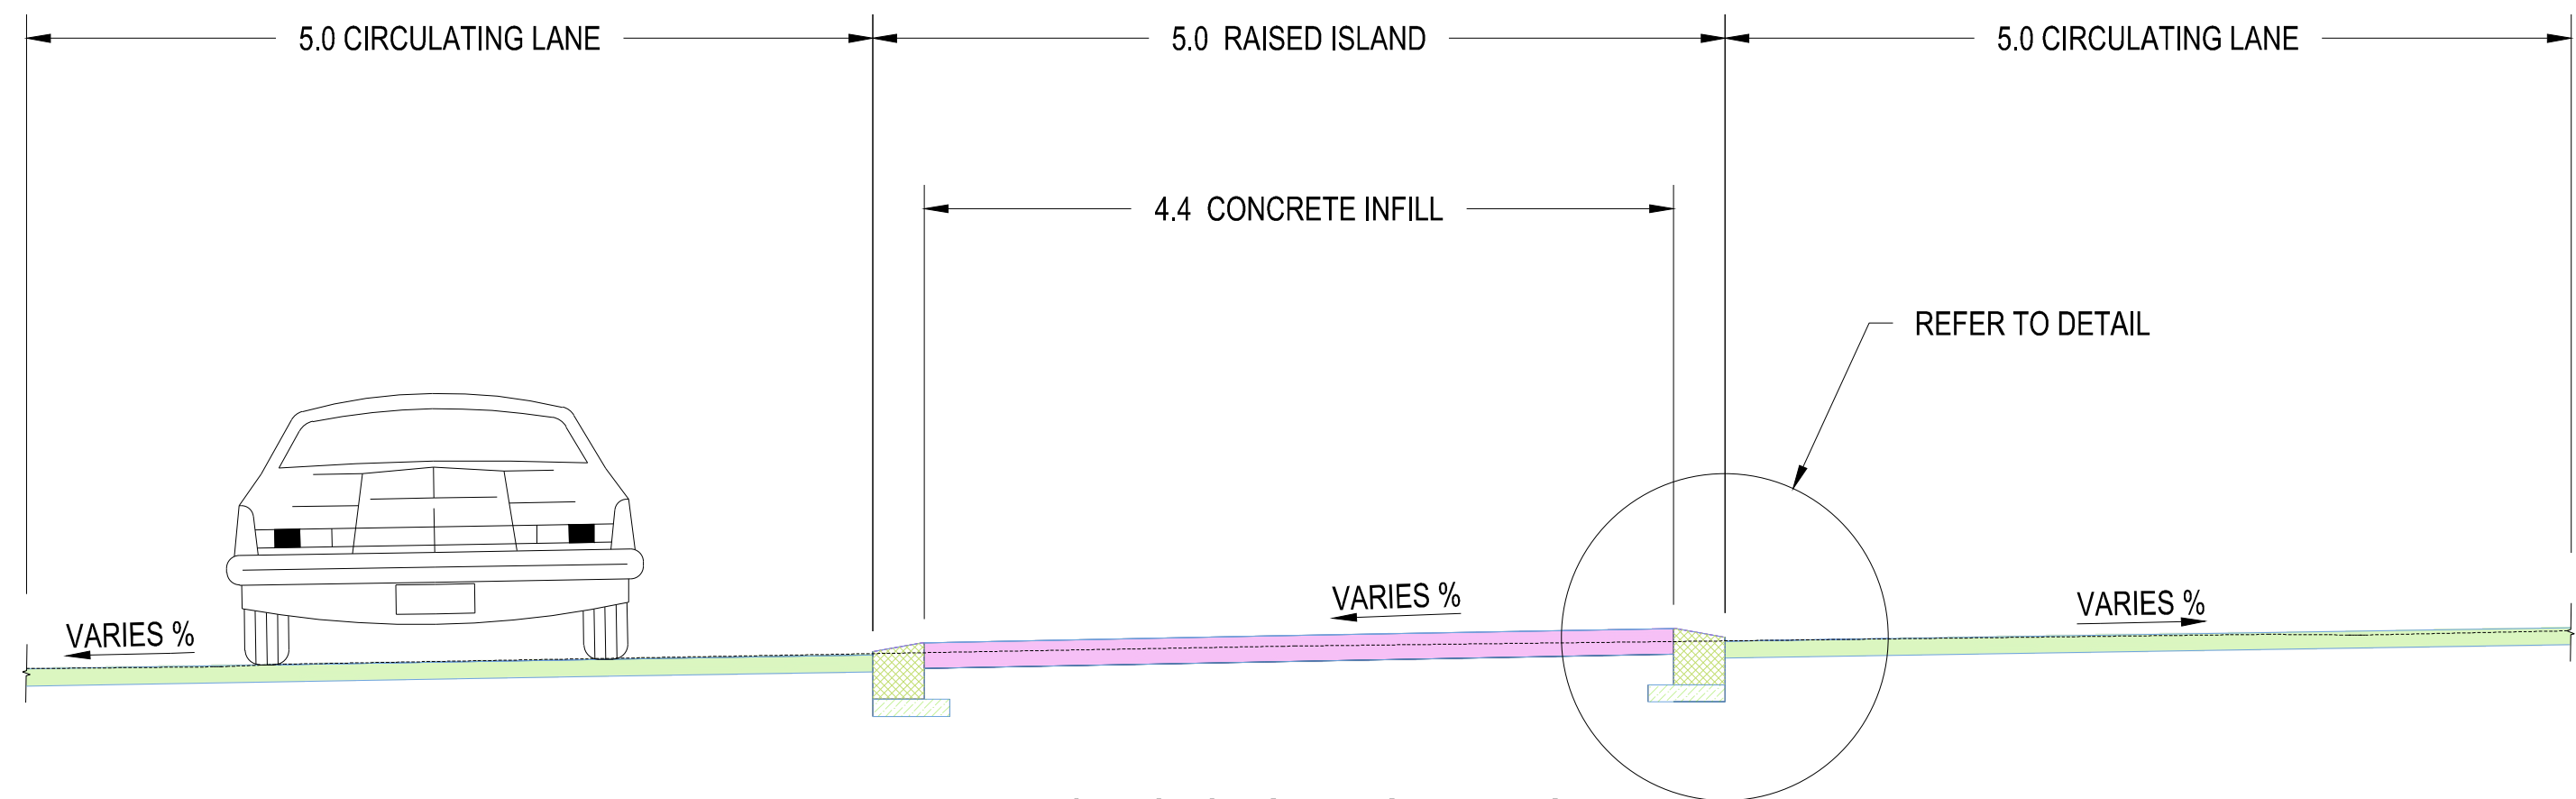

TYPICAL SECTION - ROUNDBABOUT
SCALE 1:40

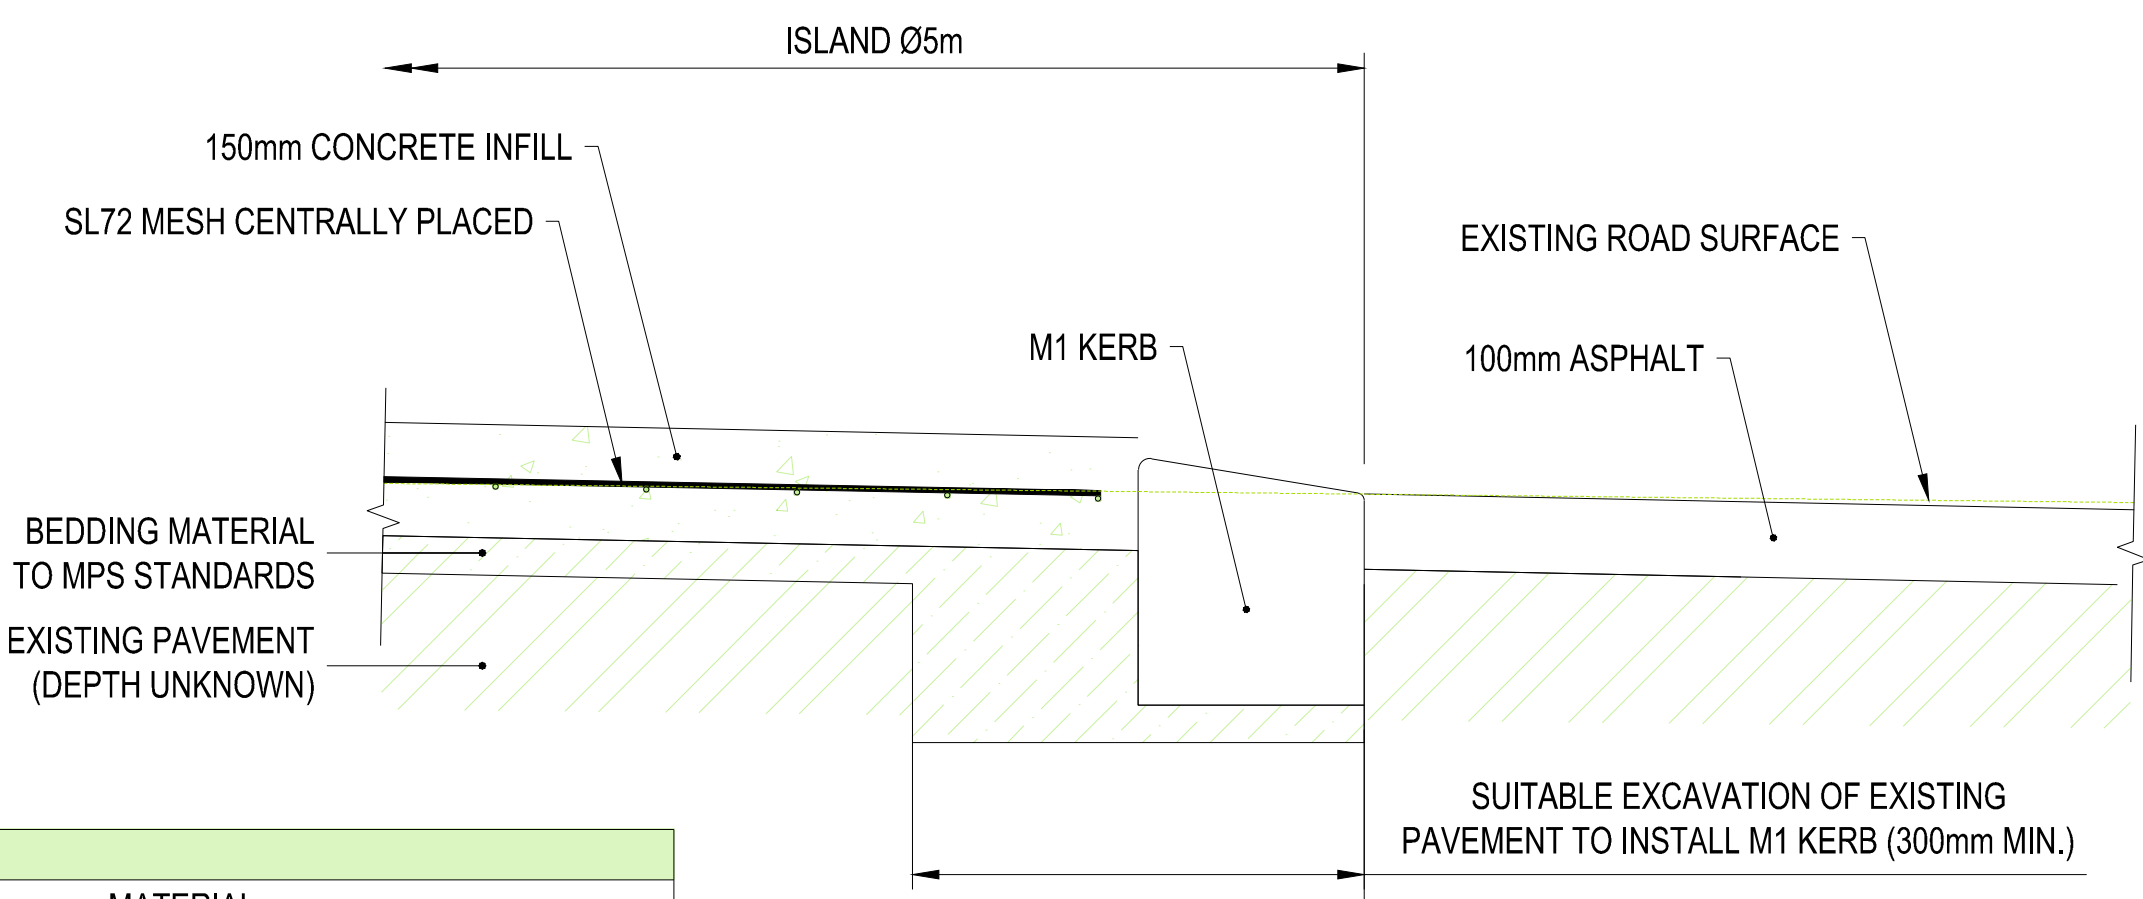


COMPACT ROUNDBABOUT CENTRAL ISLAND
N.T.S.

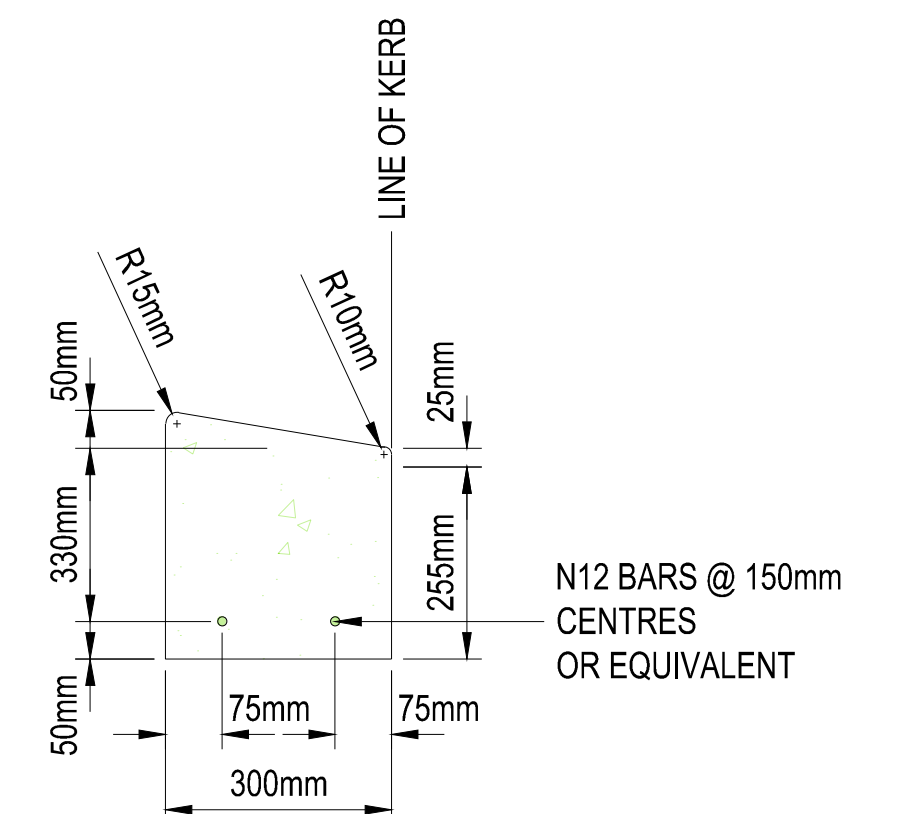

DTP M1 KERB (MODIFIED)
N.T.S.

TENDER

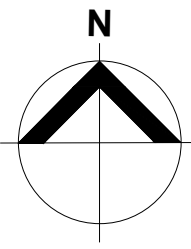

LIMIT OF WORKS

POTTON AVENUE


KEOGH STREET

LIMIT OF WORKS

LIMIT OF WORKS

- PAVEMENT TYPE 1
 - PAVEMENT TYPE 2 - ASPHALT RAISED CUSHION
 - PAVEMENT TYPE 3 - CONCRETE ISLAND
 - PAVEMENT TYPE 4 - CONCRETE FOOTPATH
 - PAVEMENT TYPE 5 - REINSTATEMENT IN FRONT OF REPLACED KERB & CHANNEL
- # EXTENT OF KERB & CHANNEL REPLACEMENT TO BE CONFIRMED ON SITE AND APPROVED BY SUPERINTENDENT. LENGTHS SHOWN ARE APPROXIMATE ONLY.

TENDER

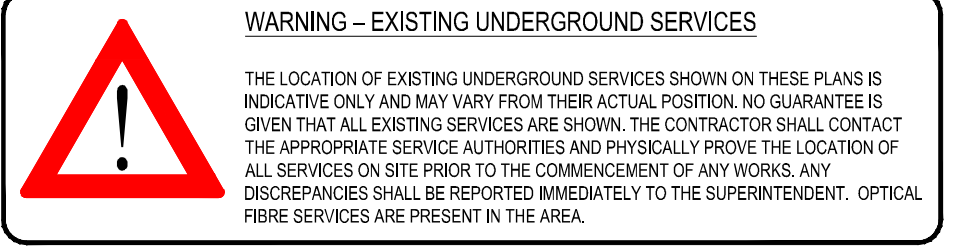

LEGEND			
	TELSTRA POLE		FIRE HYDRANT
	TELSTRA PIT		WATER STOP VALVE
	PHONE BOX		GAS VALVE
	POWER POLE		SEWER MANHOLE
	LIGHT POLE		EX WATER MAIN
	LANTERN		EX GAS MAIN
	UNDERGROUND POWER PIT		EX U/GROUND TELSTRA CABLE
	FIRE PLUG		EX SEWER MAIN
	EX U/GROUND ELECTRICITY CABLE		PROPOSED KERB AND CHANNEL
	EX OVERHEAD POWER CABLE		EXISTING KERB AND CHANNEL
	PROPOSED WATER MAIN		TREE
	PROPOSED GAS MAIN		TREE TO BE REMOVED
	PROPOSED U/G TELSTRA CABLE		PROPOSED DRAINAGE
	PROPOSED SEWER MAIN		EXISTING DRAINAGE
	PROPOSED U/G ELECTRICITY CABLE		PIT NUMBER
	PERMANENT SURVEY MARK		PROPOSED HOUSE DRAIN

REGISTERED ENGINEERS DETAILS	
NAME:	Michael Robins
SIGNATURE:	
ENG. REG.:	0008852
COMPANY:	Mornington Peninsula Shire

INTERNAL REFERENCES			
PROJECT QA:	26036		
CONTRACT CN:			
CIVIL 3D DWG:	26036-04		
SURVEY:			
DRAWN:	M. ROBINS		
DESIGN:	M. ROBINS		
CHECKED:	A. WAKILUZAMAN		
DRAWING REVISION DETAILS			
NO.	DES	CHKD	APPD
DATE			

INTERNAL REFERENCES			
PROJECT QA:	26036		
CONTRACT CN:			
CIVIL 3D DWG:	26036-04		
SURVEY:			
DRAWN:	M. ROBINS		
DESIGN:	M. ROBINS		
CHECKED:	A. WAKILUZAMAN		



SAFE LOCAL ROADS AND STREET PROGRAM	
ROSEBUD	
KEOGH STREET & POTTON AVENUE	
GENERAL ARRANGEMENT AND SPEED CUSHION SETOUT	


DATUM:	AHD
PROJECTION:	55/2020
DATE OF PLAN:	7/13/2026
SCALE AT A1:	1:100
SHEET No. 04 OF 13	
PLAN REF No.	REV
26036-04	B

SPEED CUSHION CONTROL POINTS			
POINT NO.	EASTING	NORTHING	LEVEL
1	317408.132	5751838.120	10.269
2	317410.132	5751838.096	10.238
3	317410.155	5751839.996	10.143
4	317408.155	5751840.020	10.181
5	317408.650	5751839.614	10.291
6	317408.637	5751838.514	10.343
7	317409.637	5751838.502	10.324
8	317409.650	5751839.602	10.272
9	317408.089	5751834.947	10.149
10	317410.089	5751834.919	10.118
11	317410.116	5751836.819	10.242
12	317408.116	5751836.847	10.269
13	317408.610	5751836.440	10.337
14	317409.610	5751836.426	10.323
15	317409.594	5751835.326	10.252
16	317408.594	5751835.340	10.266
17	317445.729	5751837.848	10.731
18	317447.729	5751837.831	10.819
19	317447.745	5751839.731	10.746
20	317445.745	5751839.748	10.650
21	317447.242	5751839.335	10.838
22	317446.242	5751839.344	10.790
23	317446.232	5751838.244	10.835
24	317447.232	5751838.235	10.881
25	317445.692	5751834.542	10.651
26	317447.692	5751834.518	10.752
27	317447.714	5751836.412	10.823
28	317445.715	5751836.442	10.727
29	317447.210	5751836.024	10.883
30	317446.210	5751836.036	10.832
31	317446.196	5751834.936	10.791
32	317447.196	5751834.924	10.842
33	317426.827	5751817.609	10.214
34	317426.851	5751819.008	10.200
35	317424.951	5751819.631	10.170
36	317424.927	5751817.631	10.184
37	317426.445	5751819.113	10.272
38	317425.345	5751819.126	10.255
39	317425.333	5751818.126	10.262
40	317426.433	5751818.113	10.279
41	317428.286	5751819.591	10.199
42	317428.263	5751817.592	10.214
43	317430.163	5751817.569	10.170
44	317430.186	5751819.569	10.152
45	317429.780	5751819.074	10.241
46	317428.689	5751819.087	10.267
47	317428.669	5751818.087	10.275
48	317429.769	5751818.074	10.249
49	317425.504	5751857.219	10.274
50	317425.487	5751855.219	10.262
51	317427.387	5751855.203	10.346
52	317427.404	5751857.202	10.360
53	317426.991	5751855.706	10.432
54	317427.000	5751856.706	10.439
55	317425.900	5751856.715	10.390
56	317425.891	5751855.716	10.383
57	317430.616	5751855.174	10.255
58	317430.633	5751857.174	10.272
59	317428.733	5751857.191	10.363
60	317428.716	5751855.191	10.348
61	317430.229	5751856.678	10.287
62	317429.129	5751856.687	10.341
63	317429.120	5751855.687	10.332
64	317430.220	5751855.678	10.279

KERB_NE									
ELEMENT	CHAINAGE	EASTING	NORTHING	BEARING	LENGTH	RADIUS	CURVE INTERSECTION ANGLE	IP EASTING	IP NORTHING
L5	0.000	317431.407	5751859.841	S00° 30' 02.01"W	11.619				
C4	11.619	317431.305	5751848.223	S44° 30' 23.12"E	11.940	7.600	090°00'50"	317431.239	5751840.621
L6	23.559	317438.840	5751840.557	S89° 30' 48.24"E	20.985				

KERB_NW									
ELEMENT	CHAINAGE	EASTING	NORTHING	BEARING	LENGTH	RADIUS	CURVE INTERSECTION ANGLE	IP EASTING	IP NORTHING
L1	0.000	317401.355	5751841.125	S89° 19' 19.60"E	16.063				
C2	16.063	317417.417	5751840.935	N45° 40' 47.16"E	11.231	7.150	089°59'50"	317424.566	5751840.851
L2	27.294	317424.651	5751848.000	N00° 40' 53.92"E	12.129				

BACK_FPTH									
ELEMENT	CHAINAGE	EASTING	NORTHING	BEARING	LENGTH	RADIUS	CURVE INTERSECTION ANGLE	IP EASTING	IP NORTHING
L13	0.000	317441.219	5751831.089	S84° 24' 33.63"W	2.480				
C8	2.480	317438.751	5751830.847	S61° 28' 15.97"W	0.240	0.300	045°52'40"	317438.625	5751830.835
L14	2.720	317438.546	5751830.735	S38° 31' 58.31"W	3.640				
C9	6.360	317436.278	5751827.888	S64° 40' 31.09"W	1.551	1.700	052°17'10"	317435.758	5751827.235
L15	7.912	317434.924	5751827.247	N89° 10' 56.13"W	13.616				
C10	21.528	317421.309	5751827.442	N67° 33' 27.38"W	1.283	1.700	043°15'00"	317420.635	5751827.451
L16	22.811	317420.151	5751827.920	N45° 55' 58.64"W	3.871				
C11	26.682	317417.370	5751830.612	N67° 19' 38.42"W	0.224	0.300	042°47'20"	317417.285	5751830.694
L17	26.906	317417.168	5751830.697	N88° 43' 18.20"W	7.944				

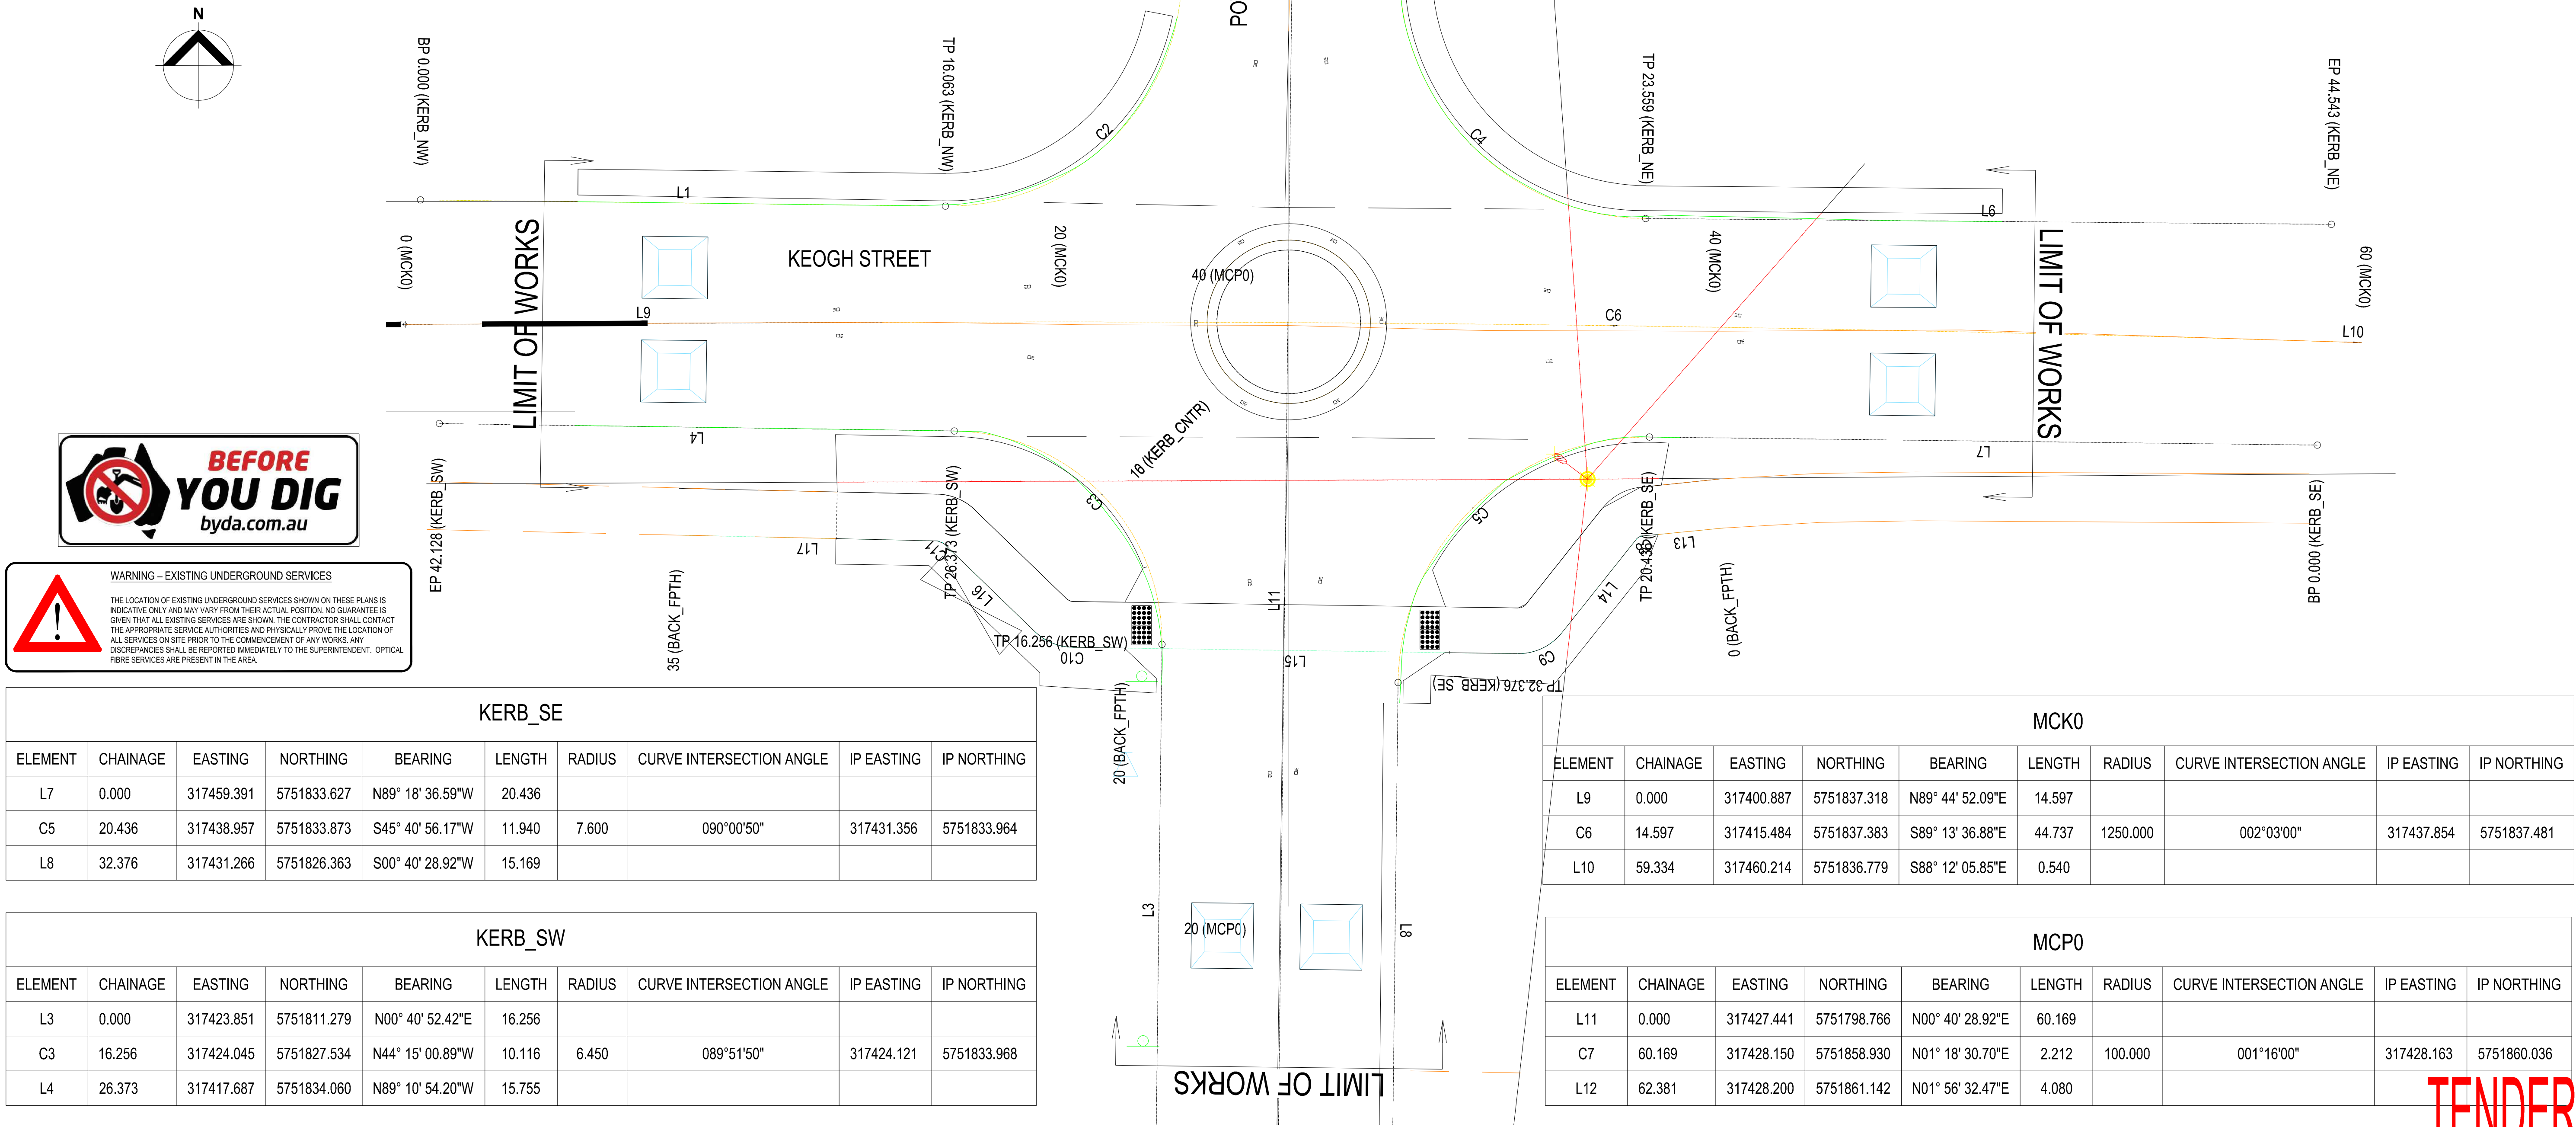

KERB_SE									
ELEMENT	CHAINAGE	EASTING	NORTHING	BEARING	LENGTH	RADIUS	CURVE INTERSECTION ANGLE	IP EASTING	IP NORTHING
L7	0.000	317459.391	5751833.627	N89° 18' 36.59"W	20.436				
C5	20.436	317438.957	5751833.873	S45° 40' 56.17"W	11.940	7.600	090°00'50"	317431.356	5751833.964
L8	32.376	317431.266	5751826.363	S00° 40' 28.92"W	15.169				

KERB_SW									
ELEMENT	CHAINAGE	EASTING	NORTHING	BEARING	LENGTH	RADIUS	CURVE INTERSECTION ANGLE	IP EASTING	IP NORTHING
L3	0.000	317423.851	5751811.279	N00° 40' 52.42"E	16.256				
C3	16.256	317424.045	5751827.534	N44° 15' 00.89"W	10.116	6.450	089°51'50"	317424.121	5751833.968
L4	26.373	317417.687	5751834.060	N89° 10' 54.20"W	15.755				

MCKO									
ELEMENT	CHAINAGE	EASTING	NORTHING	BEARING	LENGTH	RADIUS	CURVE INTERSECTION ANGLE	IP EASTING	IP NORTHING
L9	0.000	317400.887	5751837.318	N89° 44' 52.09"E	14.597				
C6	14.597	317415.484	5751837.383	S89° 13' 36.88"E	44.737	1250.000	002°03'00"	317437.854	5751837.481
L10	59.334	317460.214	5751836.779	S88° 12' 05.85"E	0.540				

MCP0									
ELEMENT	CHAINAGE	EASTING	NORTHING	BEARING	LENGTH	RADIUS	CURVE INTERSECTION ANGLE	IP EASTING	IP NORTHING
L11	0.000	317427.441	5751798.766	N00° 40' 28.92"E	60.169				
C7	60.169	317428.150	5751858.930	N01° 18' 30.70"E	2.212	100.000	001°16'00"	317428.163	5751860.036
L12	62.381	317428.200	5751861.142	N01° 56' 32.47"E	4.080				

LEGEND									
	TELSTRA POLE		FIRE HYDRANT		EX UG/GROUND ELECTRICITY CABLE		PROPOSED KERB AND CHANNEL		EXISTING HOUSE DRAIN
	TELSTRA PIT		WATER STOP VALVE		EX OVERHEAD POWER CABLE		EXISTING KERB AND CHANNEL		PROPOSED PROPERTY INLET
	PHONE BOX		GAS VALVE		PROPOSED WATER MAIN		TREE		
	POWER POLE		SEWER MANHOLE		PROPOSED GAS MAIN		TREE TO BE REMOVED		
	LIGHT POLE		EX WATER MAIN		PROPOSED UG TELSTRA CABLE		PROPOSED DRAINAGE		
	LANTERN		EX GAS MAIN		PROPOSED SEWER MAIN		EXISTING DRAINAGE		
	UNDERGROUND POWER PIT		EX UG/GROUND TELSTRA CABLE		PROPOSED UG ELECTRICITY CABLE		PIT NUMBER		
	FIRE PLUG		EX SEWER MAIN		PERMANENT SURVEY MARK		PROPOSED HOUSE DRAIN		

REGISTERED ENGINEERS DETAILS	
NAME:	Michael Robins
SIGNATURE:	
ENG REG.:	0008852
COMPANY:	Mornington Peninsula Shire



INTERNAL REFERENCES	
PROJECT QA:	26036
CONTRACT CN:	
CIVIL 3D DWG:	26036-05
SURVEY:	
DRAWN:	M. ROBINS
DESIGN:	M. ROBINS
CHECKED:	A. WAKILUZZAMAN
B TENDER ISSUE	MR AW MR 13/07/26
A ISSUED FOR REVIEW	
No DRAWING REVISION DETAILS	DES CHKD APPD DATE

MORNINGTON PENINSULA Shire

SAFE LOCAL ROADS AND STREET PROGRAM	
ROSEBUD	
KEOGH STREET & POTTON AVENUE	
KERB HORIZONTAL SETOUT INFORMATION	

DATUM:	AHD
PROJECTION:	55/2020
DATE OF PLAN:	7/13/2026
SCALE AT A1:	1:100
SHEET No. 05 OF 13	
PLAN REF No. 26036-05	REV B

TENDER

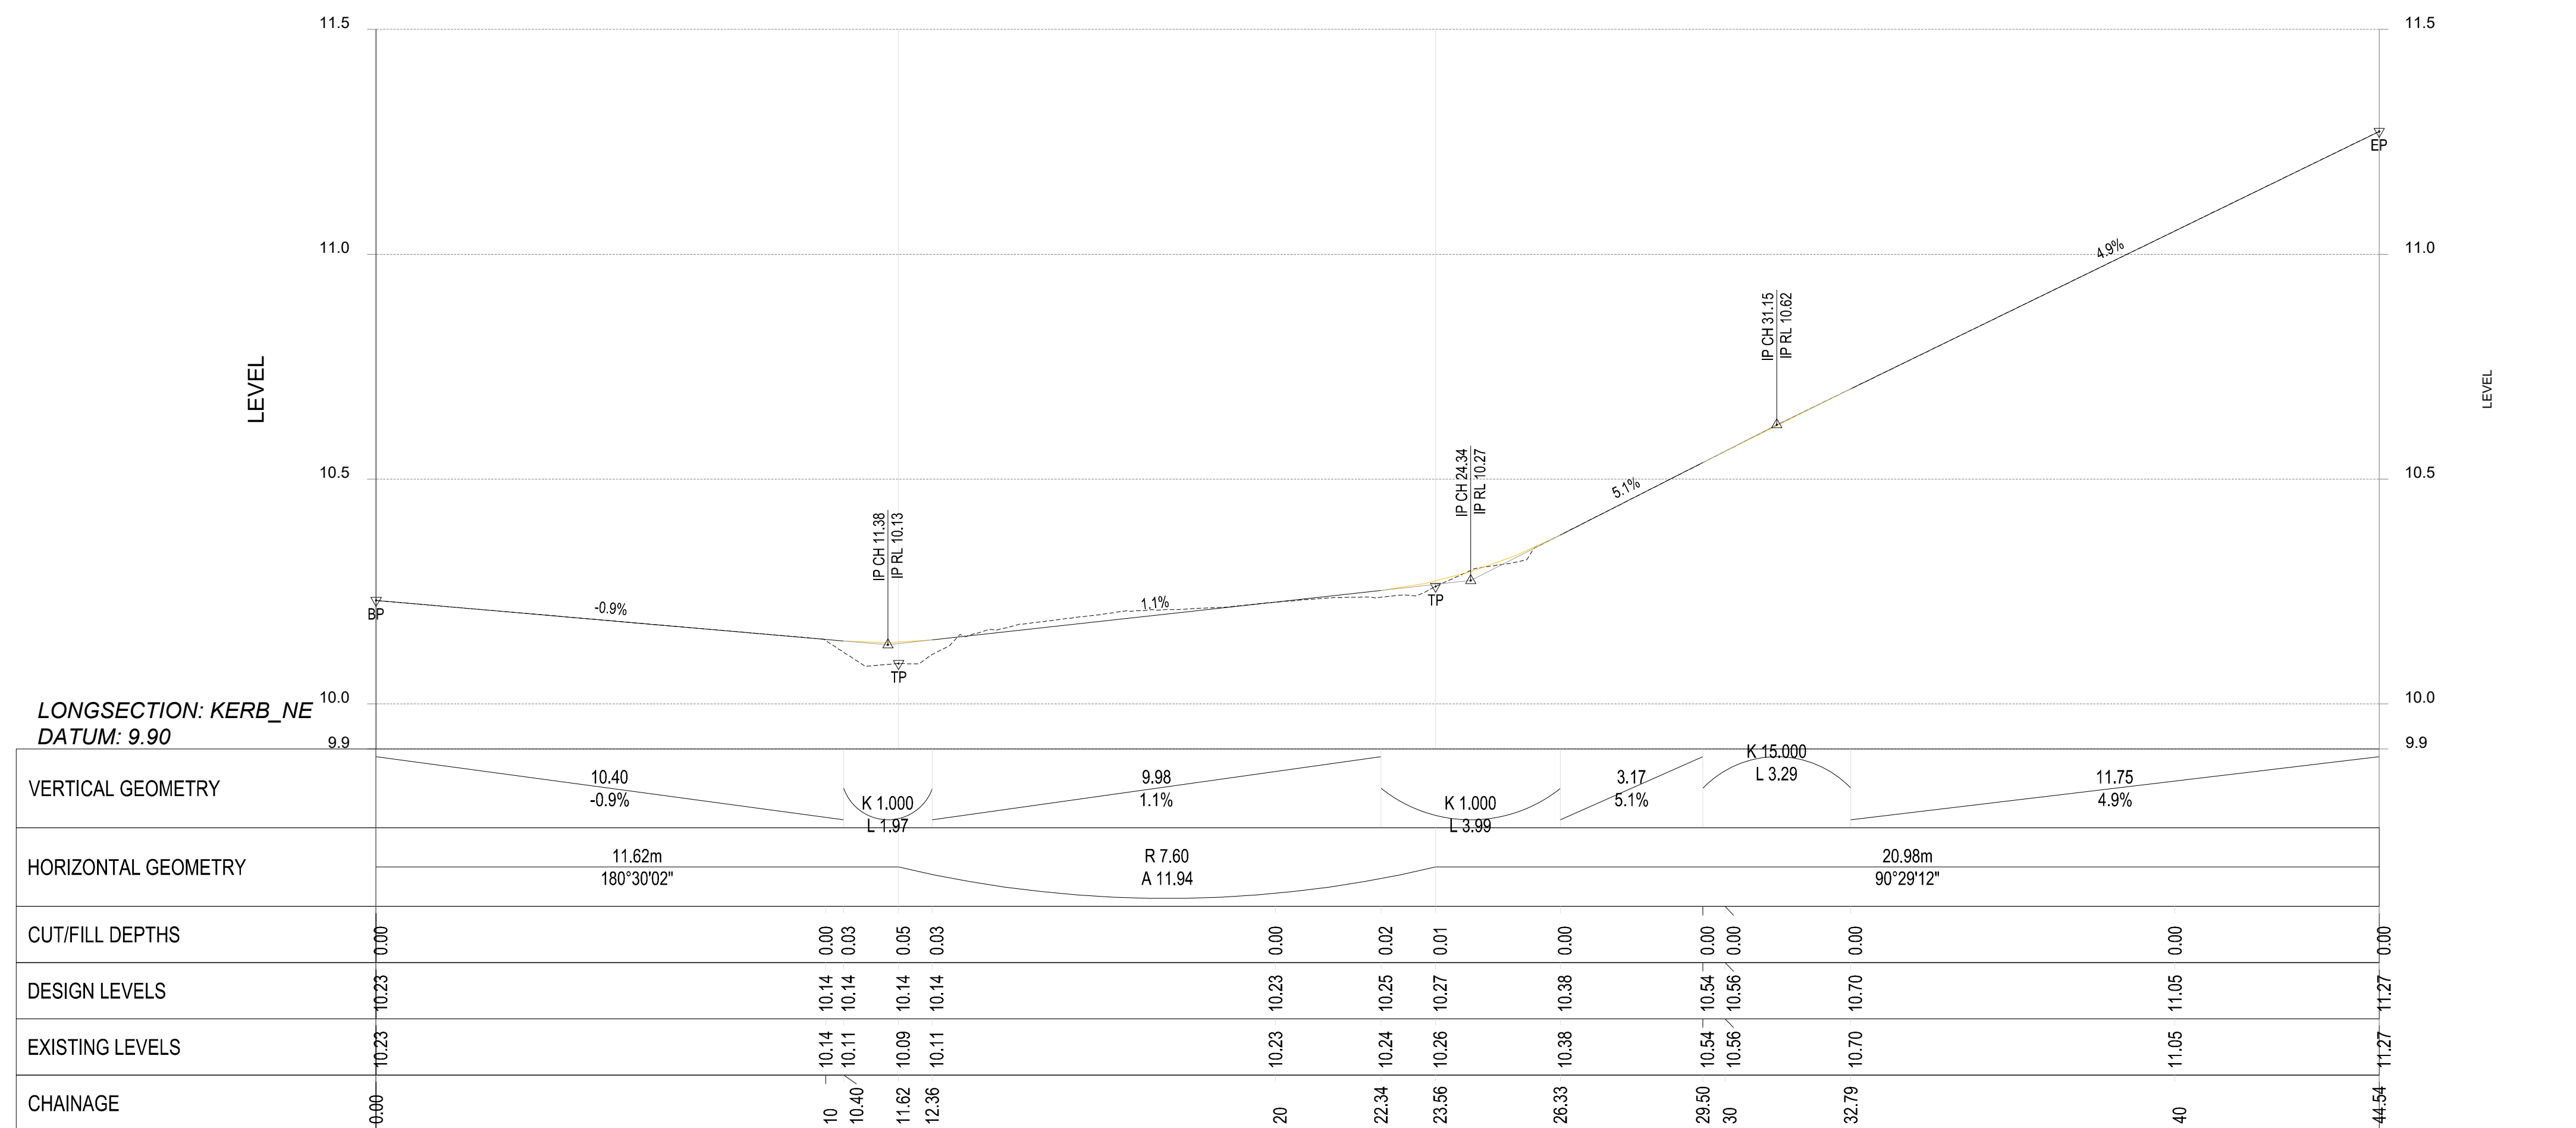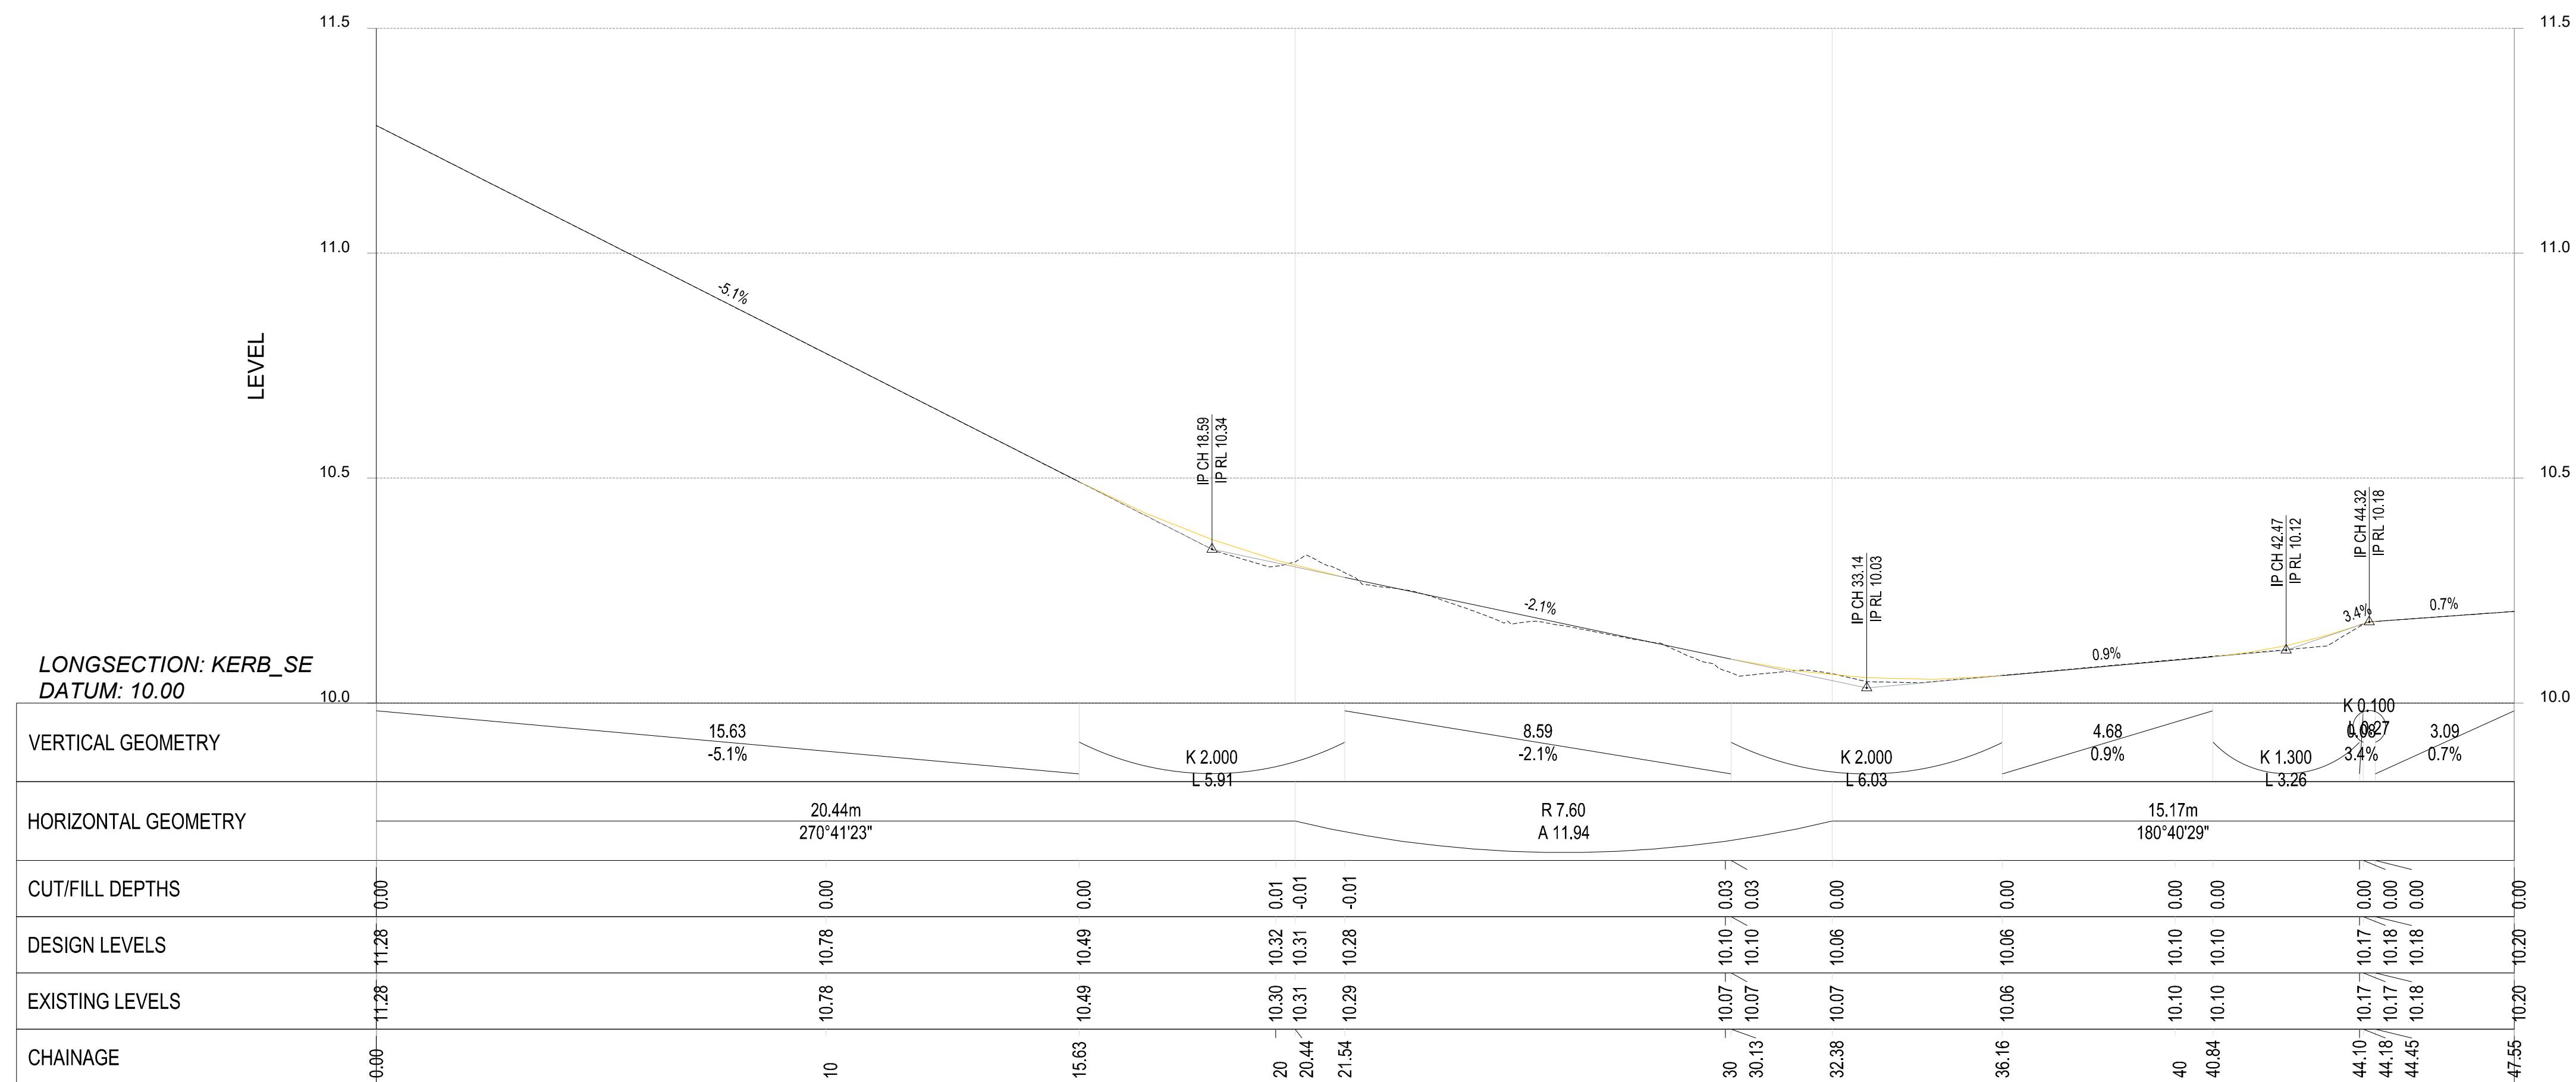

		LEGEND							
	TELSTRA POLE		FIRE HYDRANT		EX OVERHEAD ELECTRICITY CABLE		PROPOSED KERB AND CHANNEL		EXISTING HOUSE DRAIN
	TELSTRA PIT		WATER STOP VALVE		EX OVERHEAD POWER CABLE		EXISTING KERB AND CHANNEL		PROPOSED PROPERTY INLET
	PHONE BOX		GAS VALVE		PROPOSED WATER MAIN		TREE		
	POWER POLE		SEWER MANHOLE		PROPOSED GAS MAIN		TREE TO BE REMOVED		
	LIGHT POLE		EX WATER MAIN		PROPOSED UG TELSTRA CABLE		PROPOSED DRAINAGE		
	LANTERN		EX GAS MAIN		PROPOSED SEWER MAIN		EXISTING DRAINAGE		
	UNDERGROUND POWER PIT		EX UG TELSTRA CABLE		PROPOSED UG ELECTRICITY CABLE		PIT NUMBER		
	FIRE PLUG		EX SEWER MAIN		PERMANENT SURVEY MARK		PROPOSED HOUSE DRAIN		

REGISTERED ENGINEERS DETAILS	
NAME:	Michael Robins
SIGNATURE:	
ENG.REG.:	0008852
COMPANY:	Mornington Peninsula Shire

B	TENDER ISSUE			MR	AW	MR		13/07/26	
A	ISSUED FOR REVIEW								
No	DRAWING REVISION DETAILS			DES	CHKD	APPD		DATE	

INTERNAL REFERENCES	
PROJECT QA:	26036
CONTRACT CN:	
CIVIL 3D DWG:	26036-06
SURVEY:	
DRAWN:	M. ROBINS
DESIGN:	M. ROBINS
CHECKED:	A. WAKILUZZAMAN







SAFE LOCAL ROADS AND STREET PROGRAM

ROSEBUD

KEOGH STREET & POTTON AVENUE
LONGSECTIONS - KERB_SE & KERB_NE

DATUM:	AHD	
PROJECTION:	55:2020	
DATE OF PLAN:	7/13/2026	
SCALE AT A1 :	1:100	
SHEET No. 06 OF 13		
PLAN REF No. 26036-06		REV B

TENDER

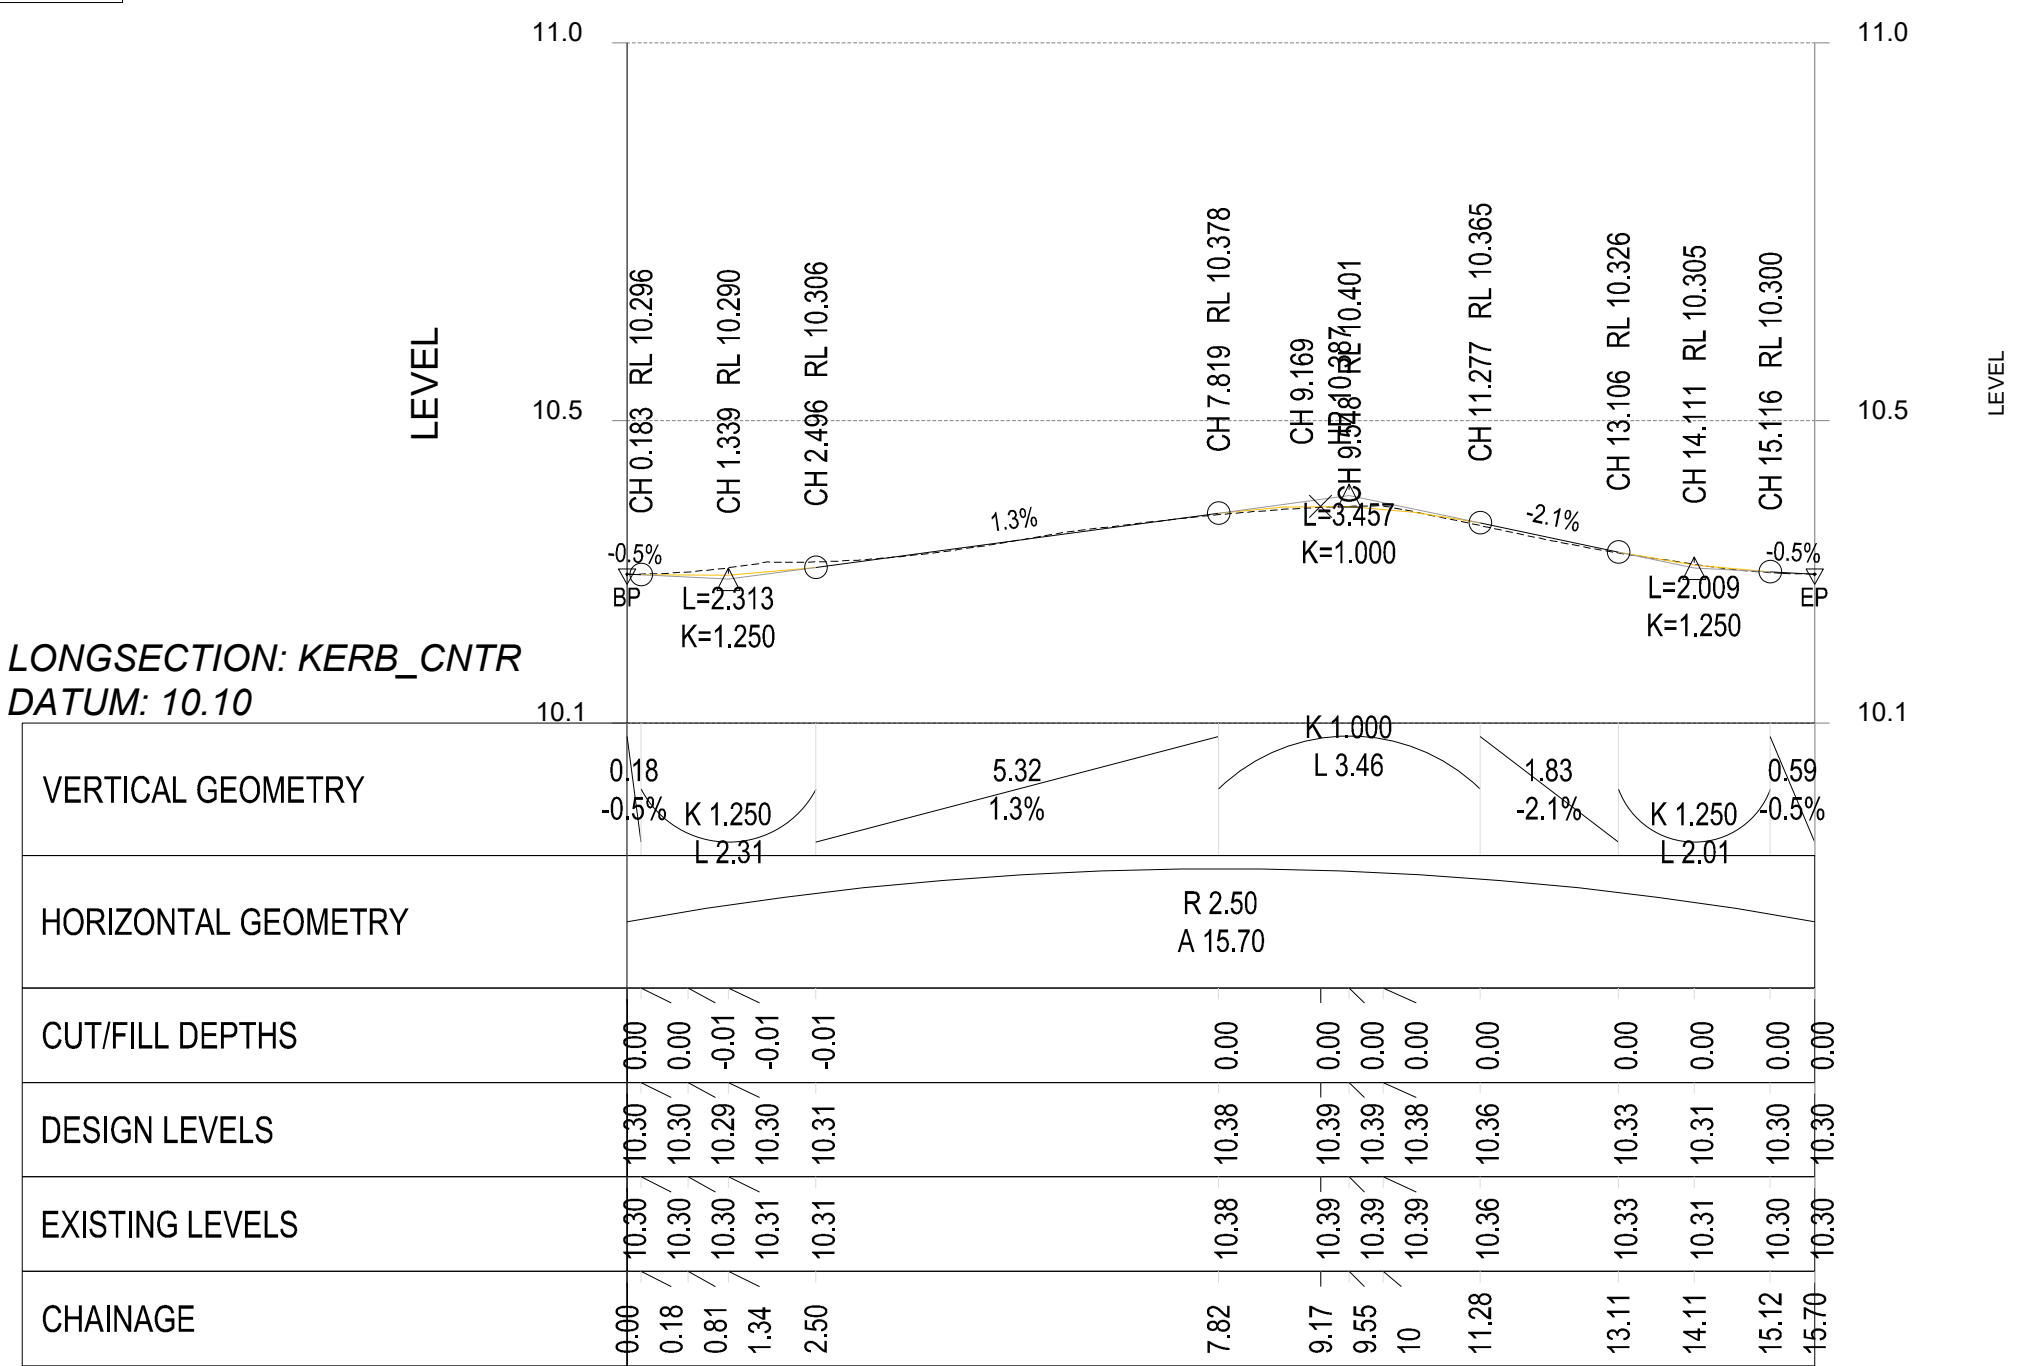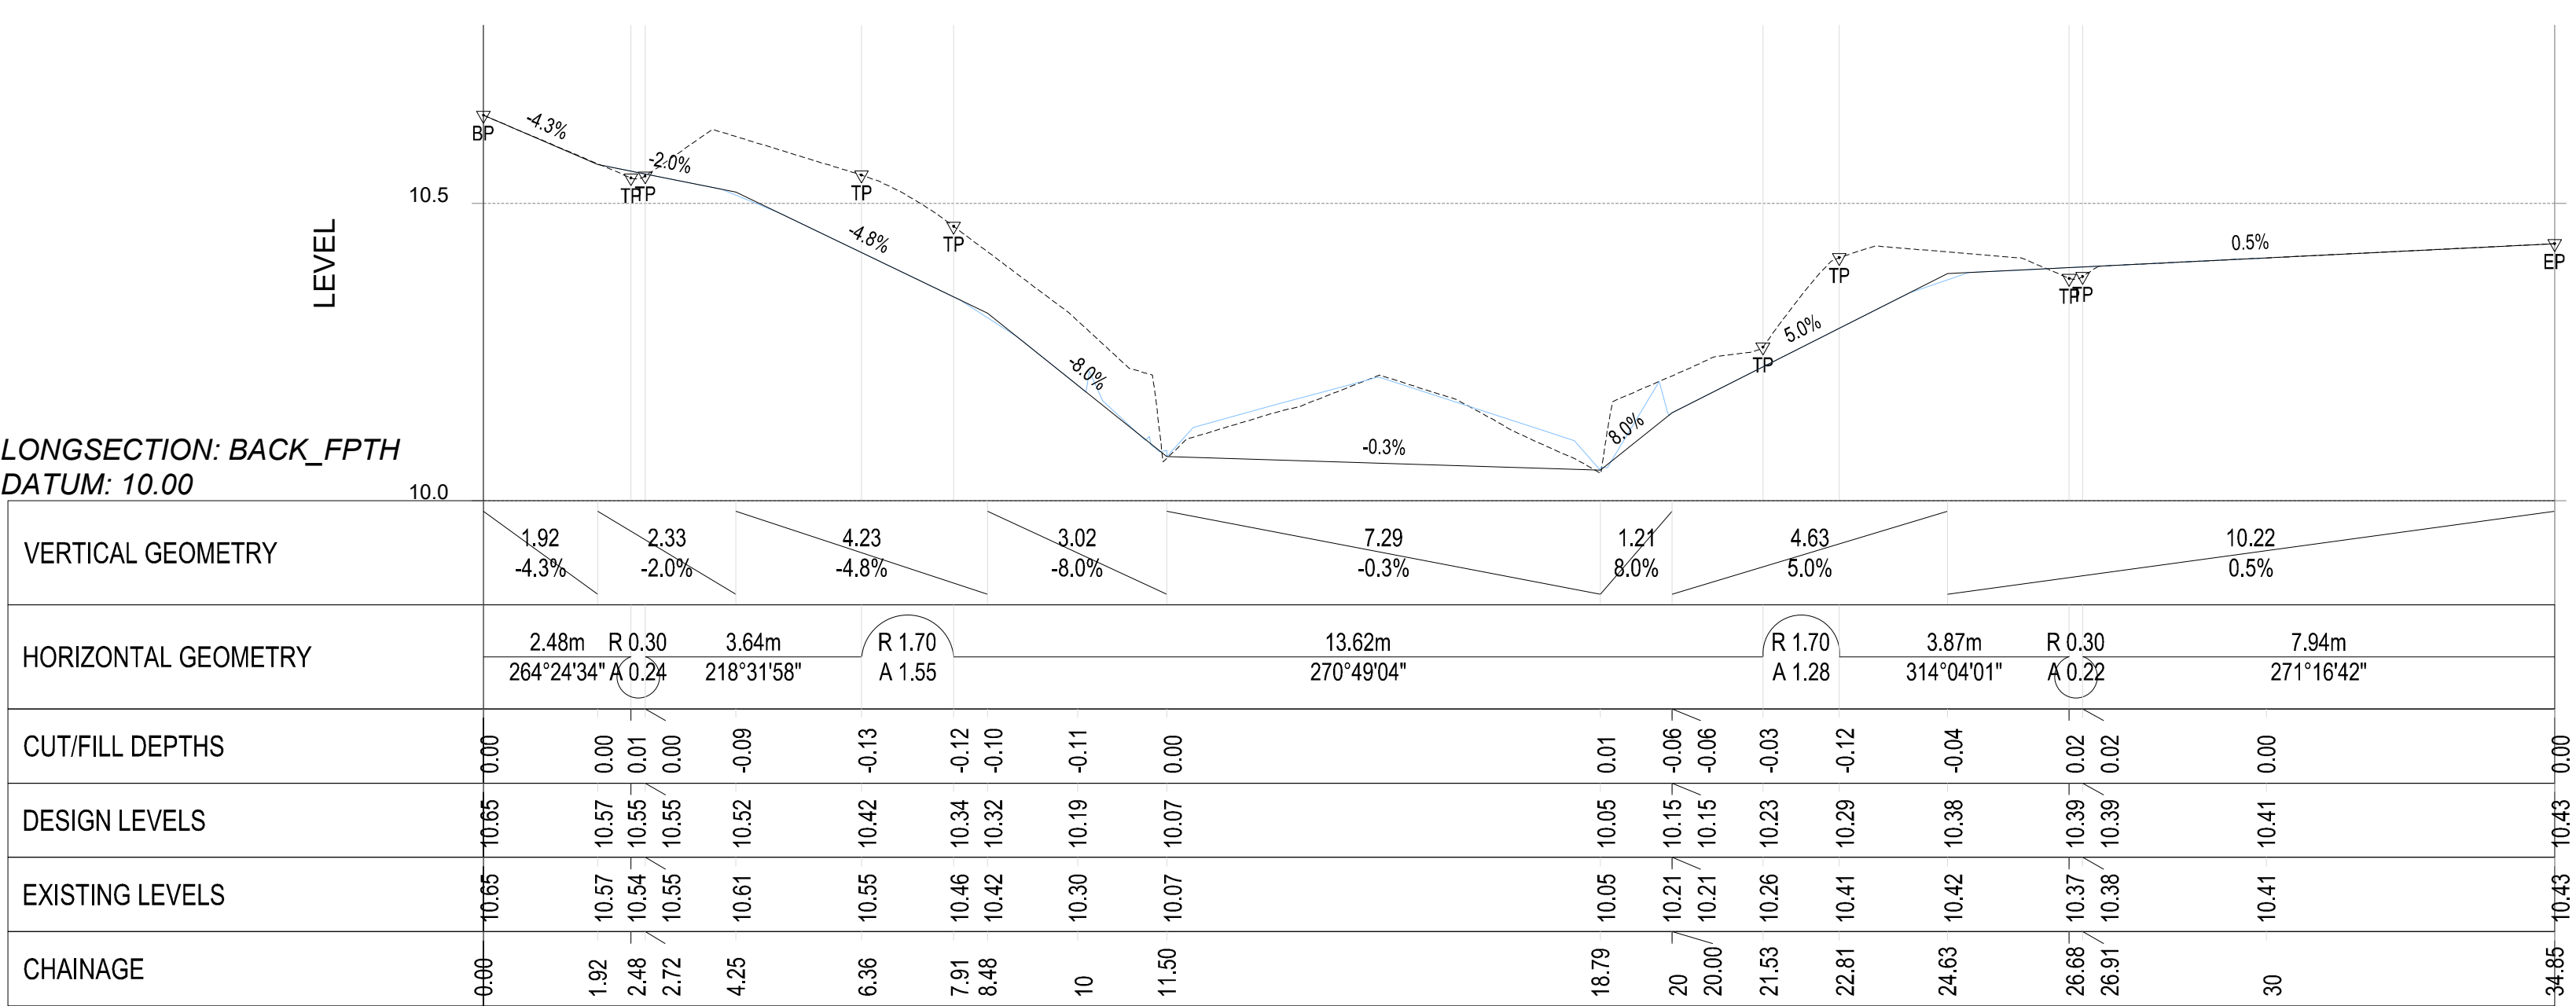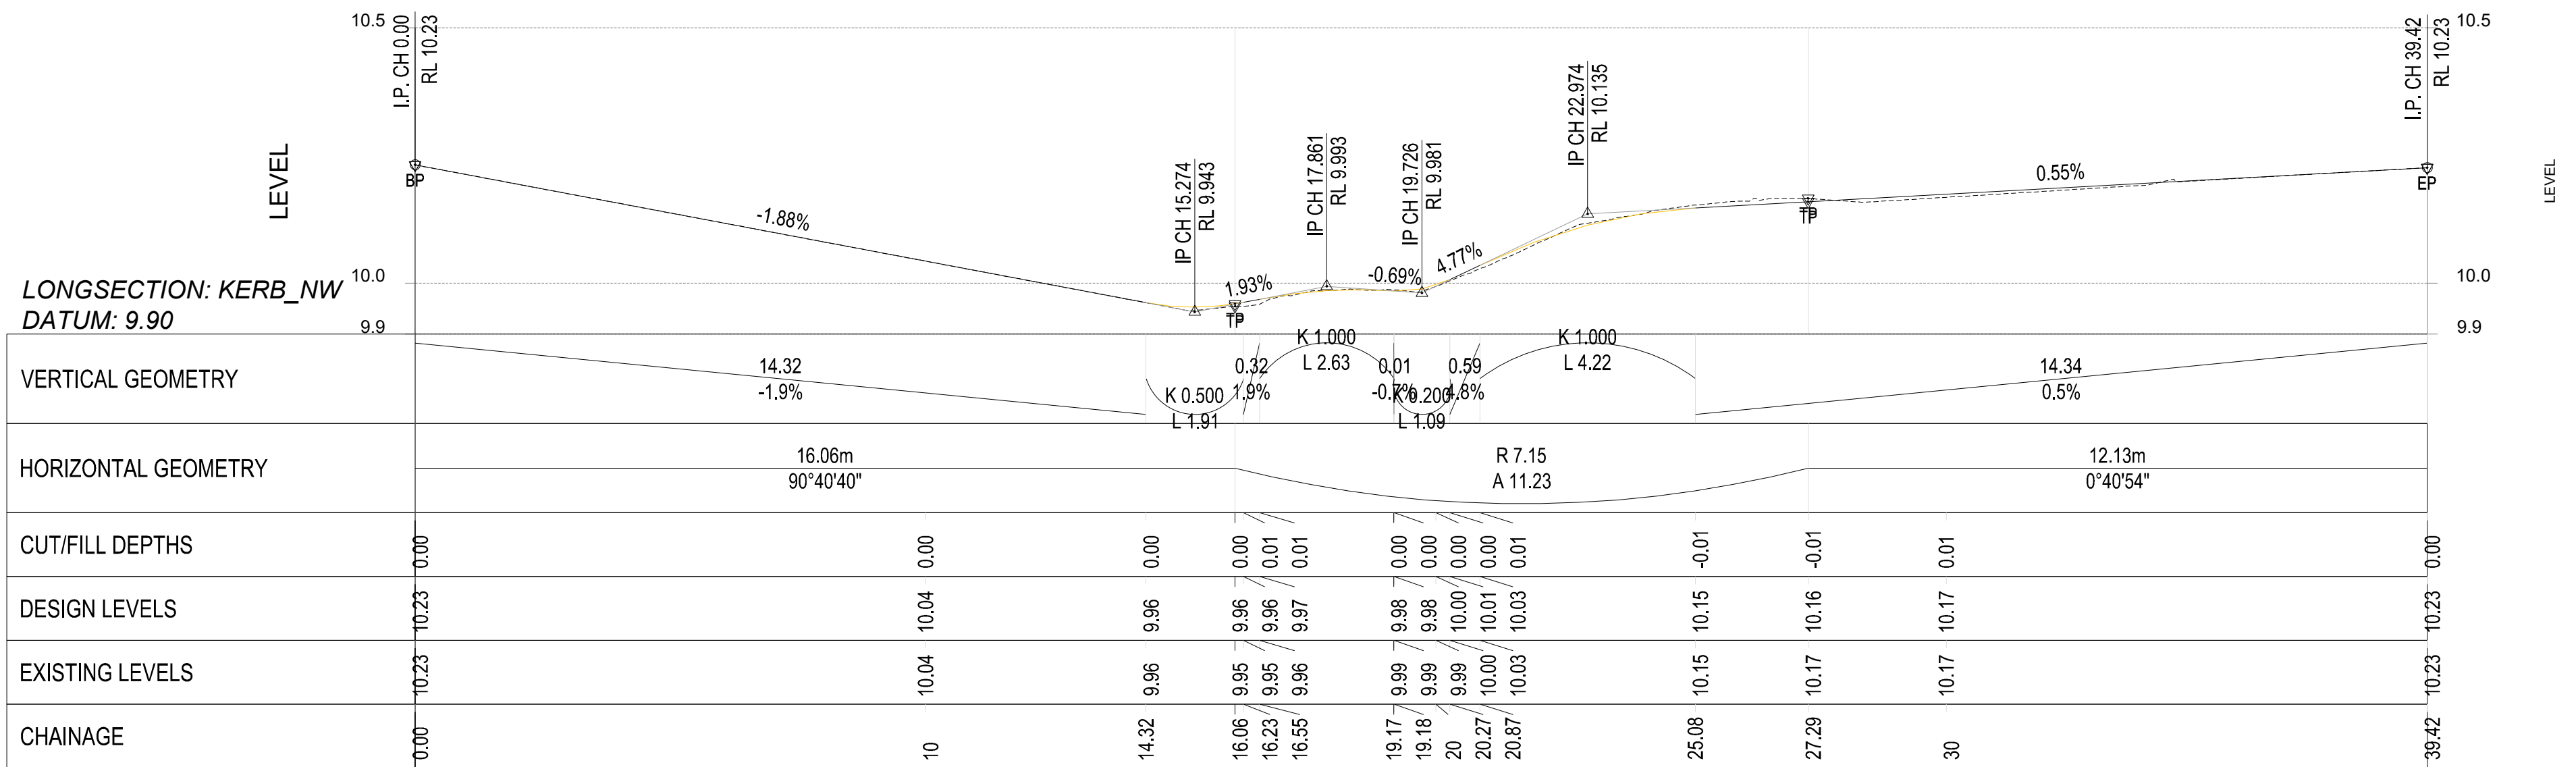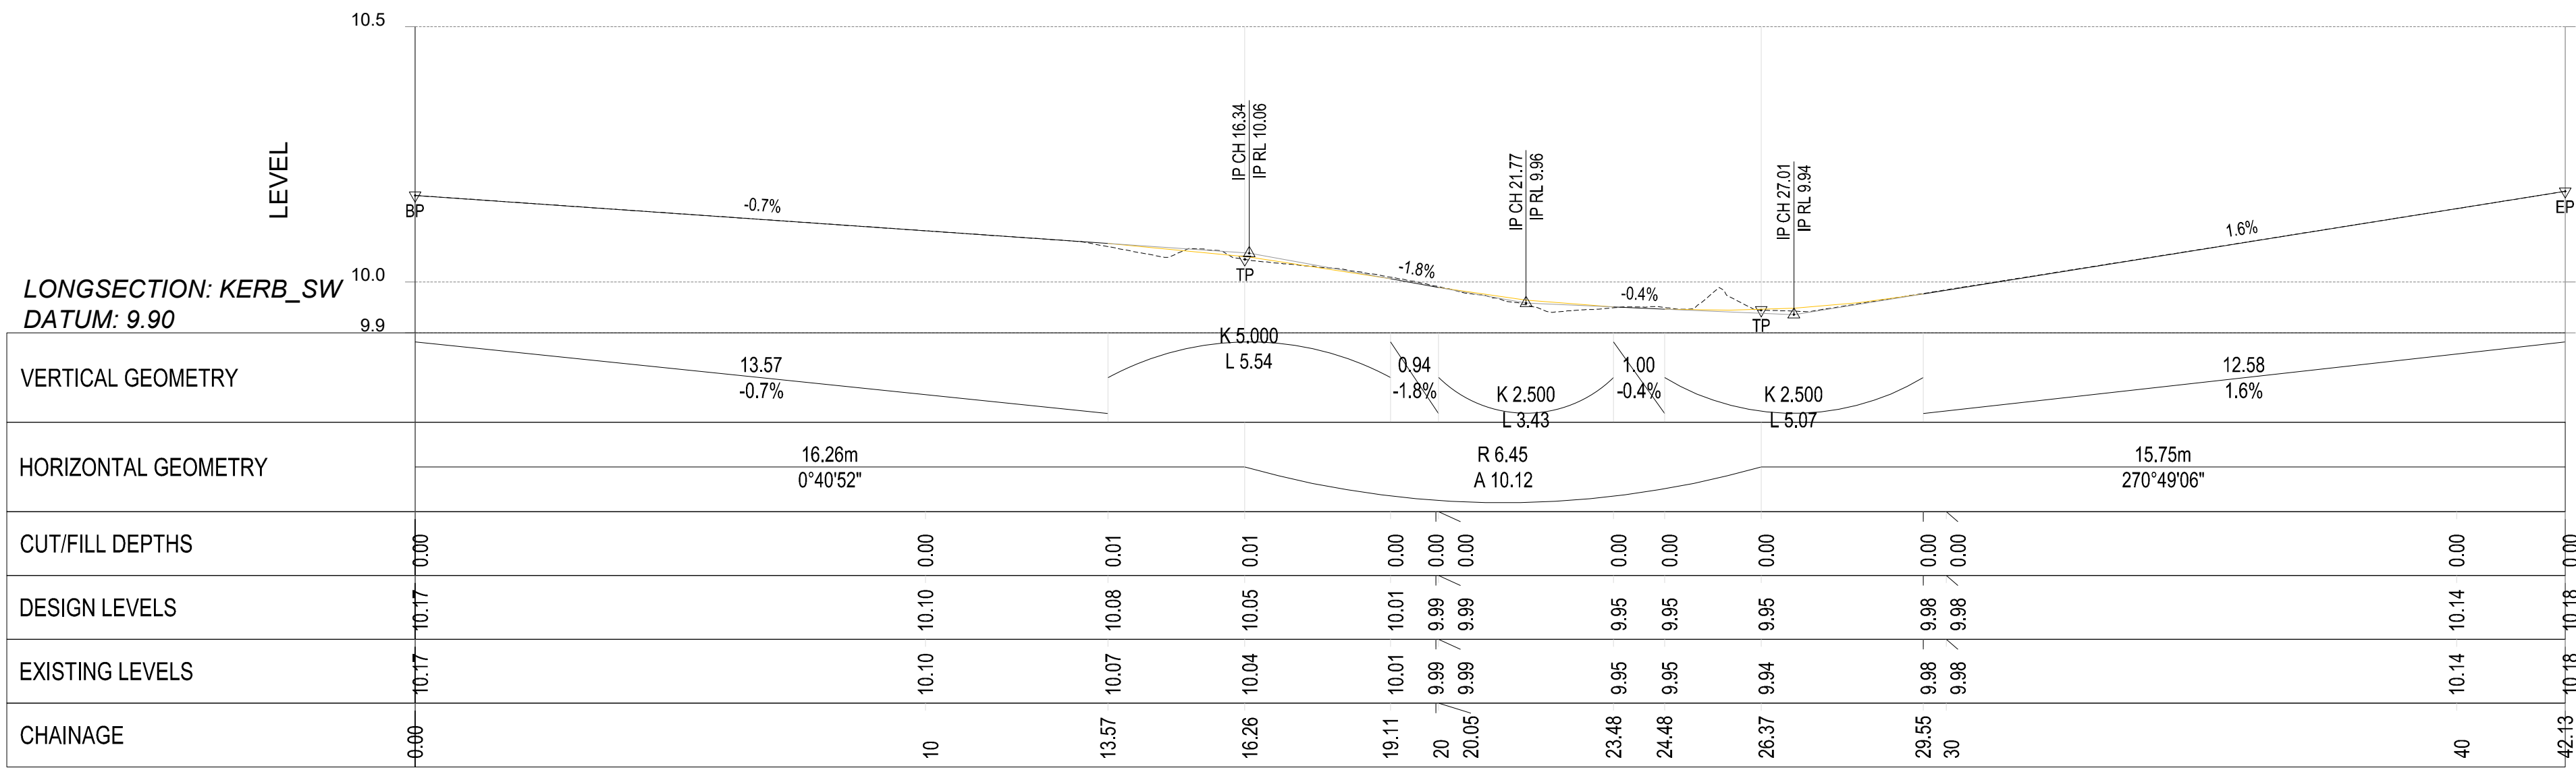

FILE PATH: K:\SIS\Design\PROJECTS\2020\26036 - Keogh Street & Potton Avenue Roundabout\2. TENDER\Kerb SW.dwg
PLOT DATE: 13/07/2026

LEGEND					
	TELSTRA POLE		FIRE HYDRANT		EX UG/GROUND ELECTRICITY CABLE
	TELSTRA PIT		WATER STOP VALVE		EX OVERHEAD POWER CABLE
	PHONE BOX		GAS VALVE		PROPOSED WATER MAIN
	POWER POLE		SEWER MANHOLE		PROPOSED GAS MAIN
	LIGHT POLE		EX WATER MAIN		PROPOSED UG TELSTRA CABLE
	LANTERN		EX GAS MAIN		PROPOSED SEWER MAIN
	UNDERGROUND POWER PIT		EX UG/GROUND TELSTRA CABLE		PROPOSED UG ELECTRICITY CABLE
	FIRE PLUG		EX SEWER MAIN		PERMANENT SURVEY MARK
			PROPOSED KERB AND CHANNEL		EXISTING KERB AND CHANNEL
			TREE		TREE TO BE REMOVED
			EXISTING DRAINAGE		PROPOSED DRAINAGE
			PIT NUMBER		PROPOSED HOUSE DRAIN

REGISTERED ENGINEERS DETAILS	
NAME:	Michael Robins
SIGNATURE:	
ENG REG.:	0008852
COMPANY:	Mornington Peninsula Shire



INTERNAL REFERENCES	
PROJECT QA:	26036
CONTRACT CN:	
CIVIL 3D DWG:	26036-07
SURVEY:	
DRAWN:	M. ROBINS
DESIGN:	M. ROBINS
CHECKED:	A. WAKILUZZAMAN

DRAWING REVISION DETAILS	
B	TENDER ISSUE
A	ISSUED FOR REVIEW
No	
DES	MR
CHKD	AW
APPD	MR
DATE	13/07/26



SAFE LOCAL ROADS AND STREET PROGRAM
ROSEBUD
KEOGH STREET & POTTON AVENUE
LONGSETCTIONS - KERB_SW, KERB_NW, KERB_CNTR & FOOTPATH

DATUM:	AHD
PROJECTION:	55/2020
DATE OF PLAN:	7/13/2026
SCALE AT A1:	1:100
SHEET No. 07 OF 13	
PLAN REF No.	REV
26036-07	B

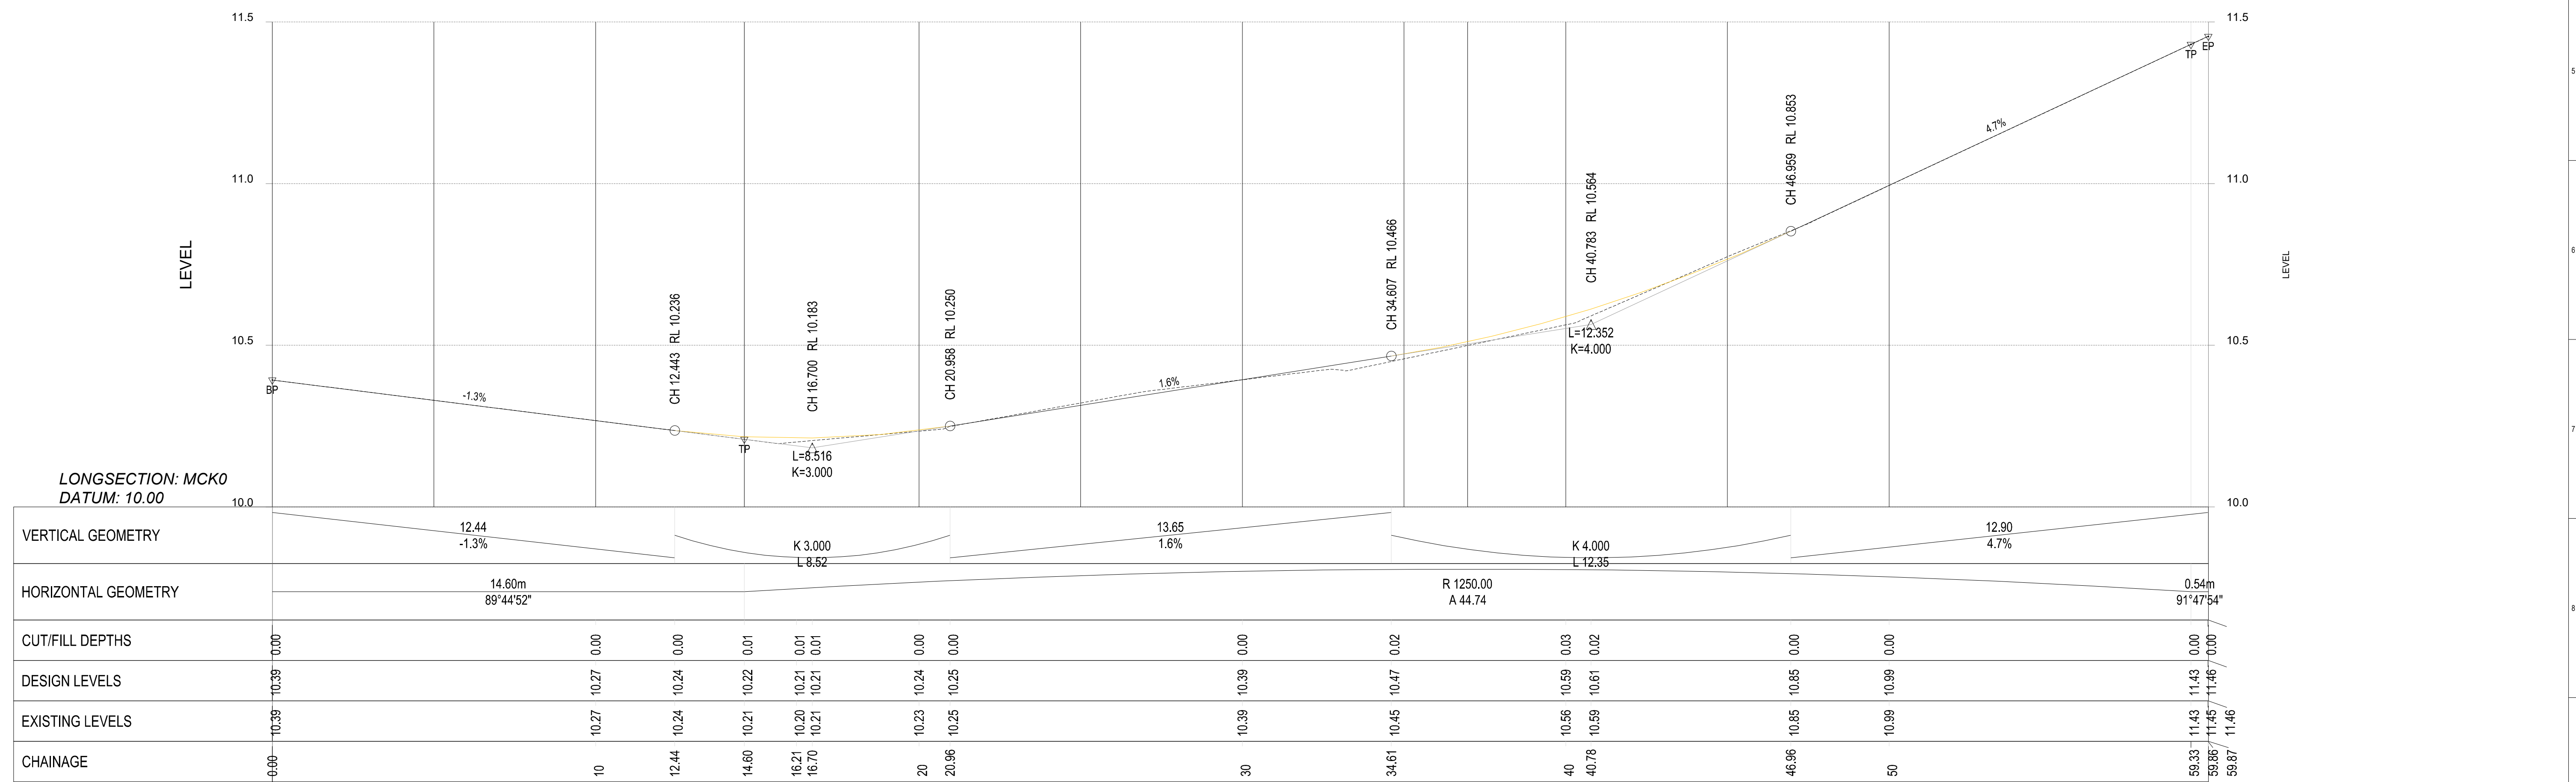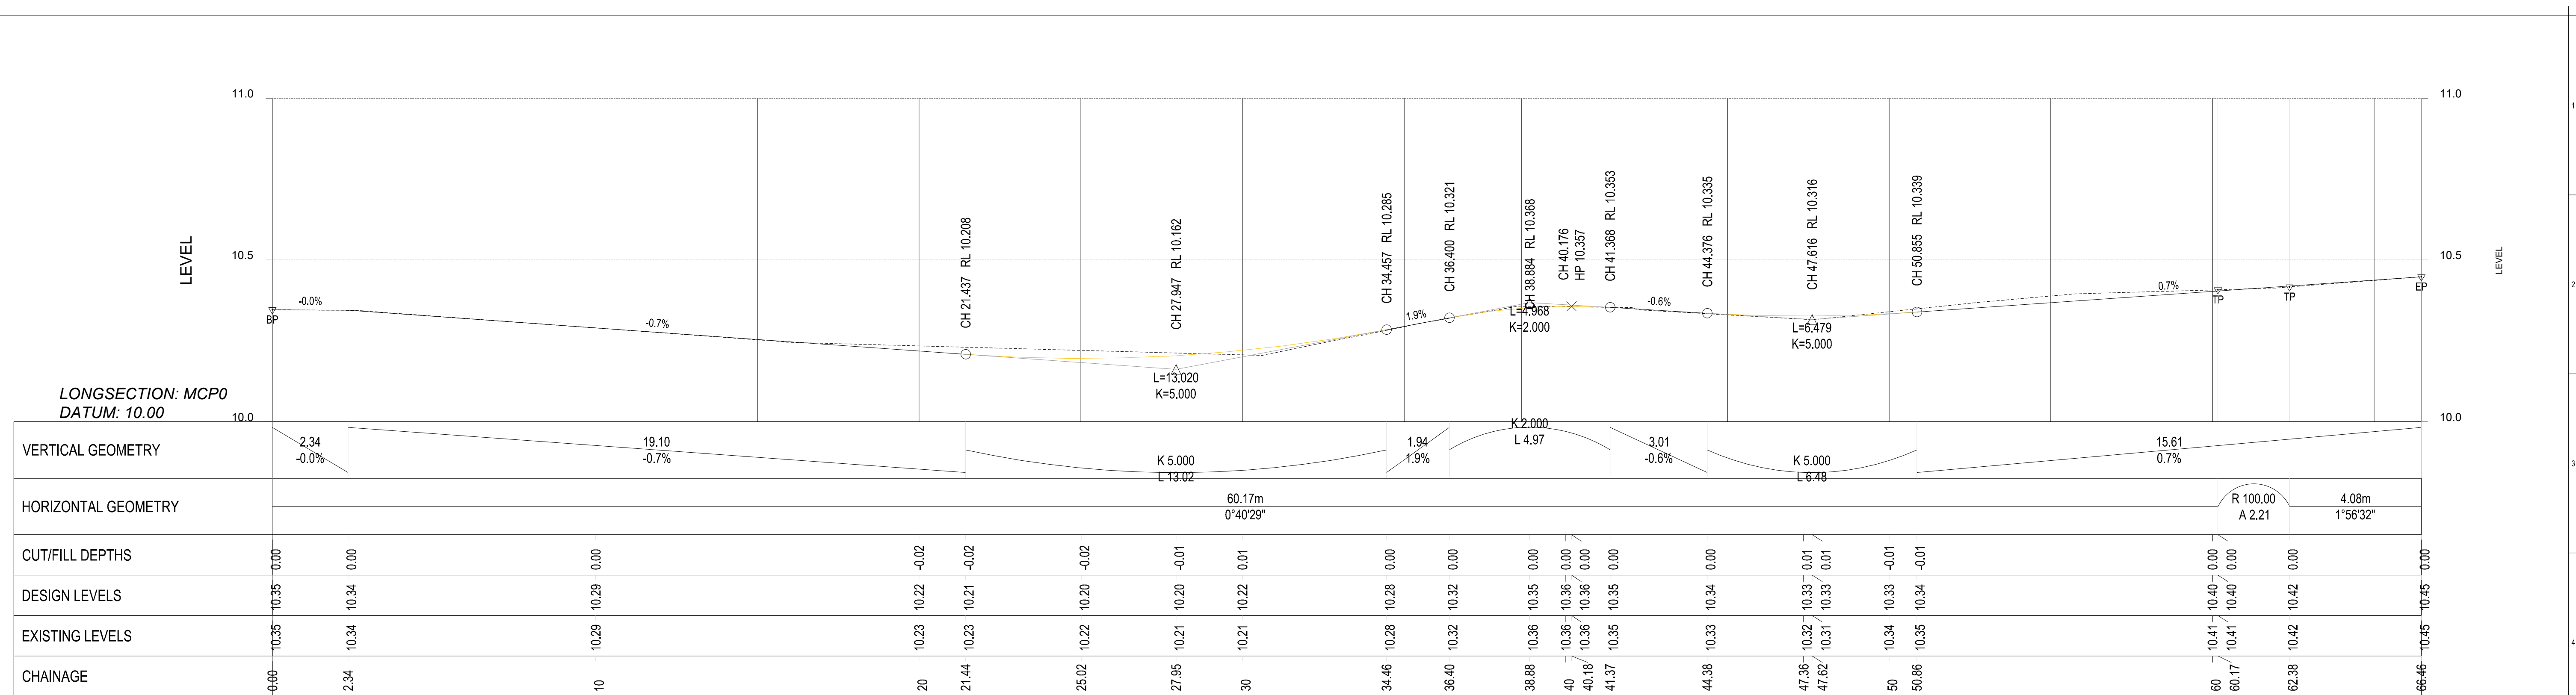

LEGEND									
	TELSTRA POLE		FIRE HYDRANT		EX UNDERGROUND ELECTRICITY CABLE		PROPOSED KERB AND CHANNEL		EXISTING HOUSE DRAIN
	TELSTRA PIT		WATER STOP VALVE		EX OVERHEAD POWER CABLE		EXISTING KERB AND CHANNEL		PROPOSED PROPERTY INLET
	PHONE BOX		GAS VALVE		PROPOSED WATER MAIN		TREE		
	POWER POLE		SEWER MANHOLE		PROPOSED GAS MAIN		TREE TO BE REMOVED		
	LIGHT POLE		EX WATER MAIN		PROPOSED UG TELSTRA CABLE		PROPOSED DRAINAGE		
	LANTERN		EX GAS MAIN		PROPOSED SEWER MAIN		EXISTING DRAINAGE		
	UNDERGROUND POWER PIT		EX U/GROUND TELSTRA CABLE		PROPOSED UG ELECTRICITY CABLE		PIT NUMBER		
	FIRE PLUG		EX SEWER MAIN		PERMANENT SURVEY MARK		PROPOSED HOUSE DRAIN		

REGISTERED ENGINEERS DETAILS	
NAME:	Michael Robins
SIGNATURE:	
ENG.REG.:	0008852
COMPANY:	Mornington Peninsula Shire

B	TENDER ISSUE	MR	AW	MR
A	ISSUED FOR REVIEW			13/07/26
No	DRAWING REVISION DETAILS	DES	CHKD	APPD

INTERNAL REFERENCES	
PROJECT QA:	26036
CONTRACT CN:	
CIVIL 3D DWG:	26036-08
SURVEY:	
DRAWN:	M. ROBINS
DESIGN:	M. ROBINS
CHECKED:	A. WAKILUZZAMAN



SAFE LOCAL ROADS AND STREET PROGRAM


ROSEBUD

KEOGH STREET & POTTON AVENUE

LONGSECTIONS - MCP0 AND MCK0

DATUM:	AHD
PROJECTION:	55:2020
DATE OF PLAN:	7/13/2026
SCALE AT A1 :	1:100
SHEET No. 08 OF 13	
PLAN REF No. 26036-08	REV B

TENDER

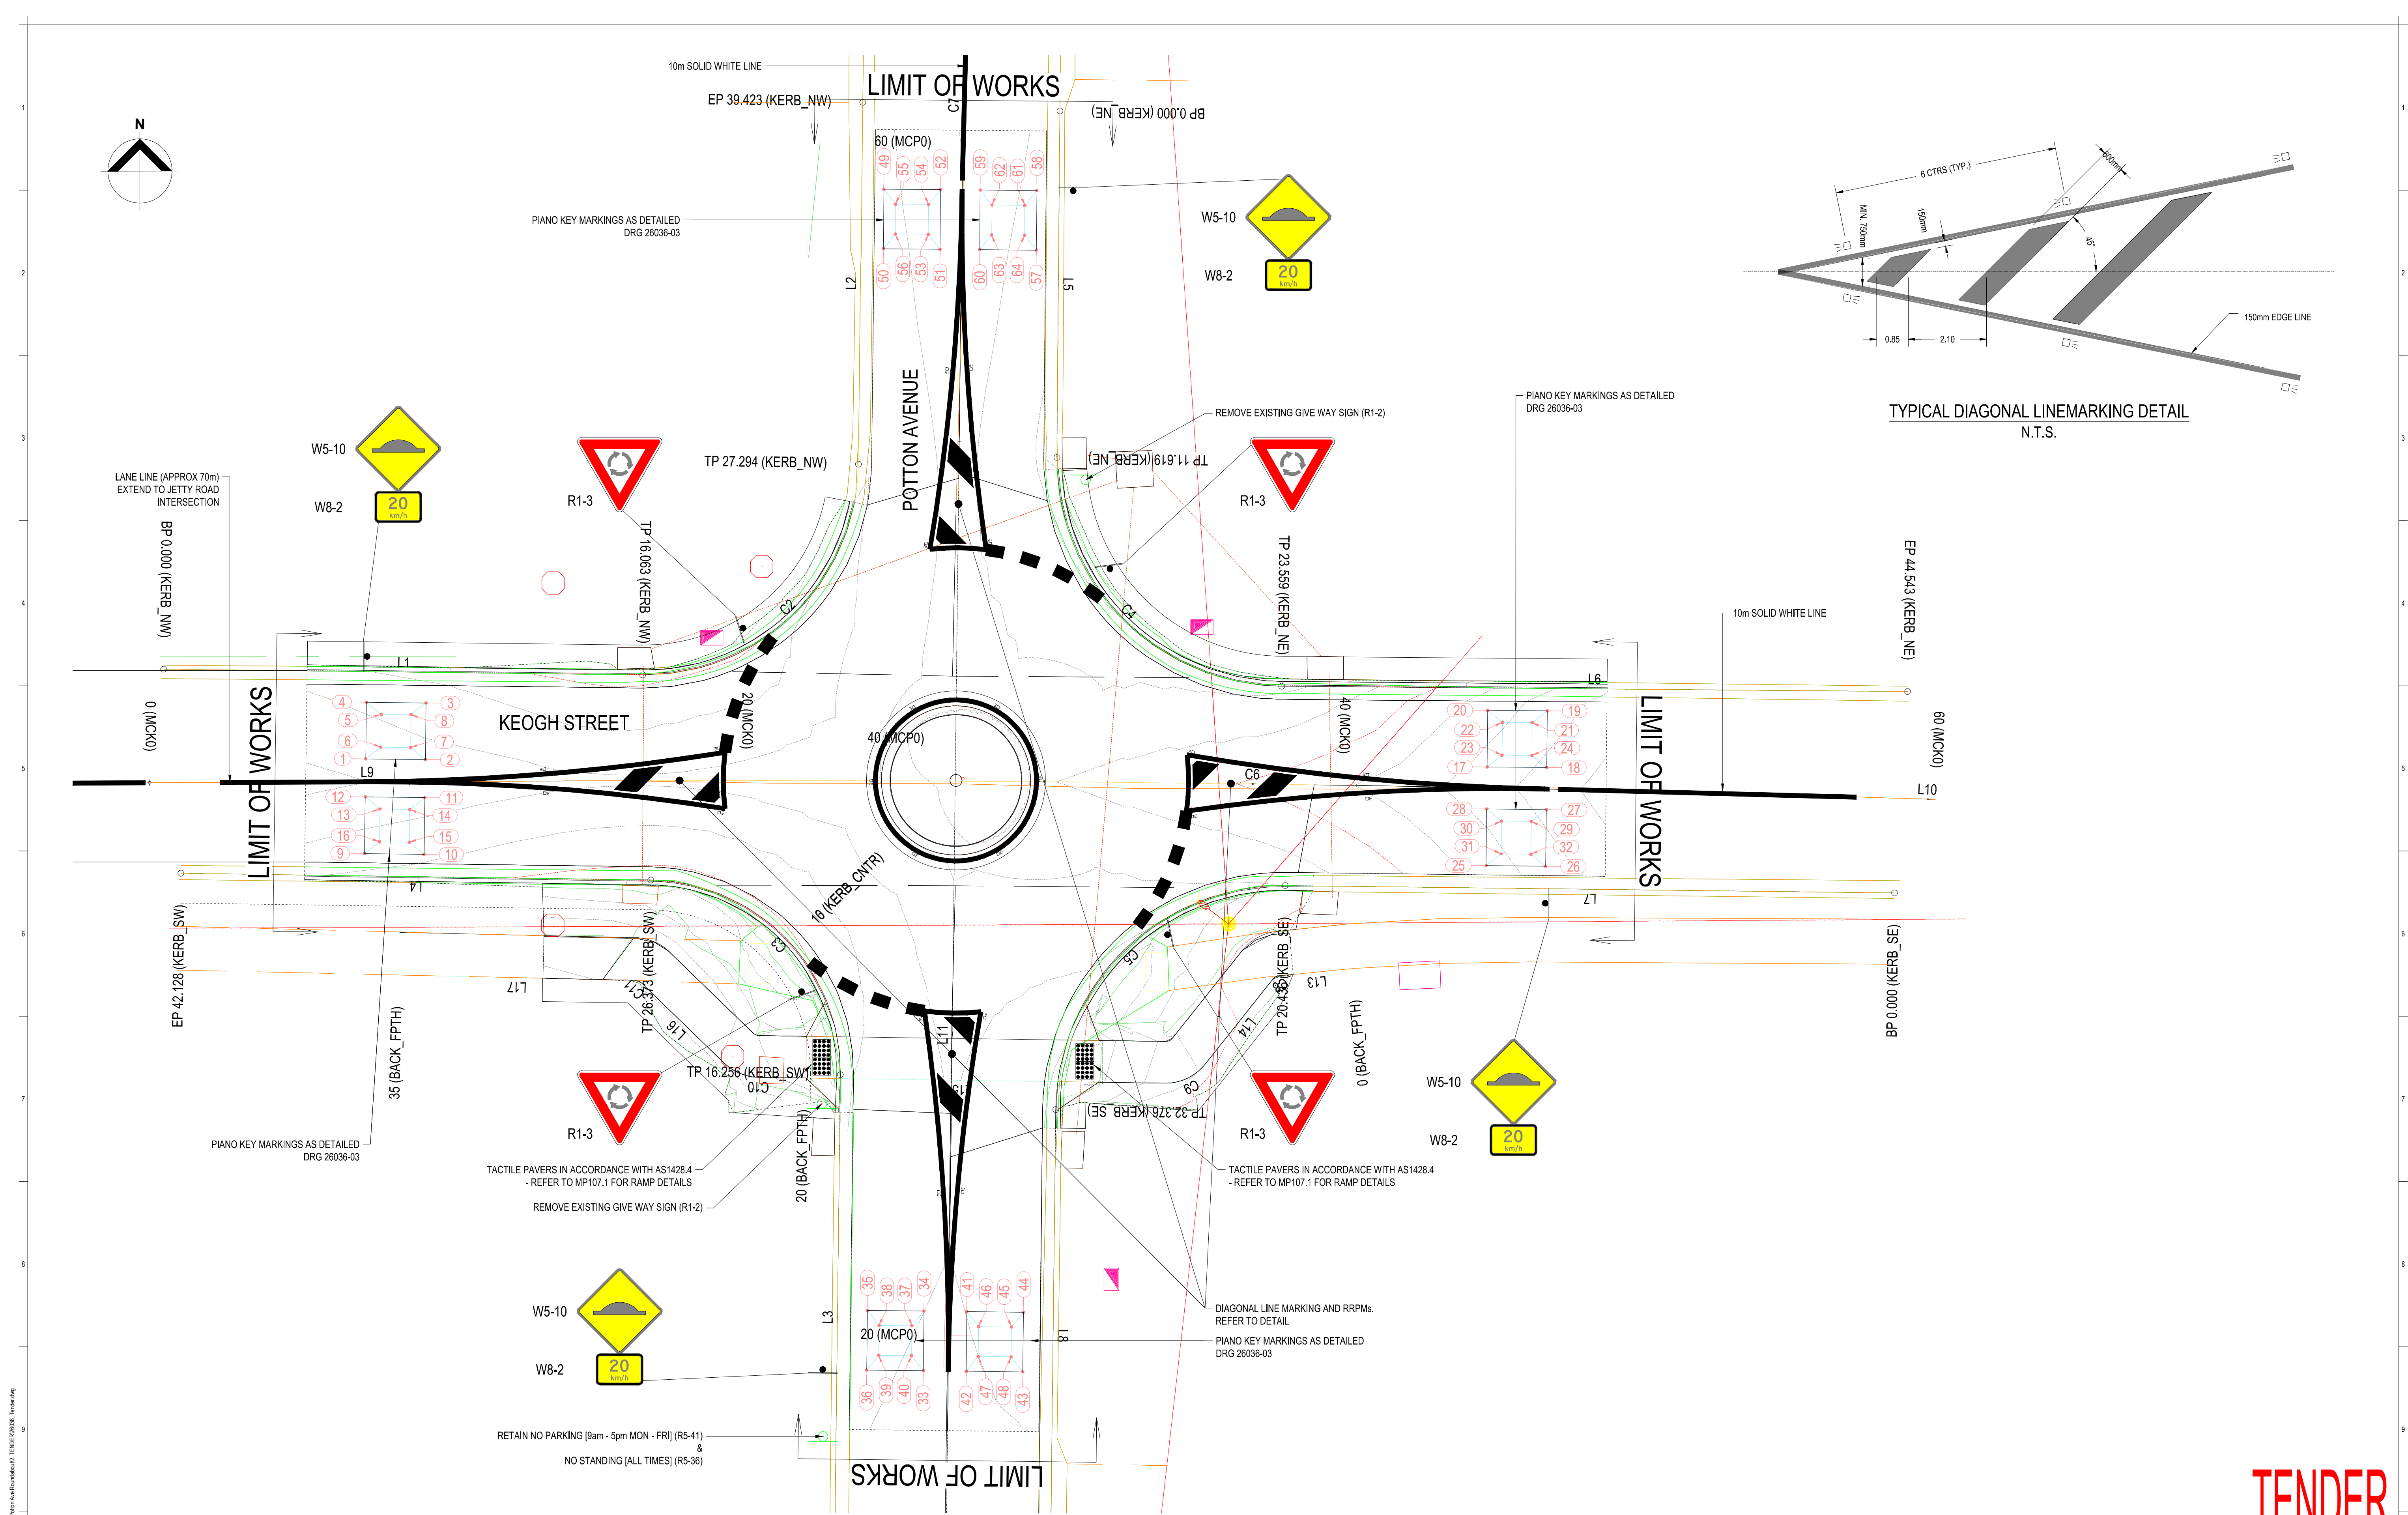

TYPICAL DIAGONAL LINEMARKING DETAIL
N.T.S.

FILE PATH: K:\S:\Design\PROJECTS\26036\26036 - Keogh Street & Potton Ave Roundabout2 - TENDER.dwg
PLOT DATE: 5/11/2025

LEGEND			
	TELSTRA POLE		FIRE HYDRANT
	TELSTRA PIT		WATER STOP VALVE
	PHONE BOX		GAS VALVE
	POWER POLE		SEWER MANHOLE
	LIGHT POLE		EX WATER MAIN
	LANTERN		EX GAS MAIN
	UNDERGROUND POWER PIT		EX U/GROUND TELSTRA CABLE
	FIRE PLUG		EX U/GROUND ELECTRICITY CABLE
	PROPOSED KERB AND CHANNEL		EXISTING KERB AND CHANNEL
	PROPOSED WATER MAIN		PROPOSED GAS MAIN
	PROPOSED U/G TELSTRA CABLE		PROPOSED DRAINAGE
	PROPOSED SEWER MAIN		EXISTING DRAINAGE
	PROPOSED U/G ELECTRICITY CABLE		PIT NUMBER
	PERMANENT SURVEY MARK		PROPOSED HOUSE DRAIN

REGISTERED ENGINEERS DETAILS	
NAME:	Michael Robins
SIGNATURE:	
ENG REG.:	0008852
COMPANY:	Mornington Peninsula Shire

INTERNAL REFERENCES	
PROJECT QA:	26036
CONTRACT CN:	
CIVIL 3D DWG:	26036-09
SURVEY:	
DRAWN:	M. ROBINS
DESIGN:	M. ROBINS
CHECKED:	A. WAKILUZZAMAN
B TENDER ISSUE	MR AW MR 13/07/26
A ISSUED FOR REVIEW	
No DRAWING REVISION DETAILS	DES CHKO APPD DATE

DES	CHKO	APPD	DATE
-----	------	------	------



SAFE LOCAL ROADS AND STREET PROGRAM


ROSEBUD

KEOGH STREET & POTTON AVENUE

SIGNS AND LINEMARKING ARRANGEMENT


DATUM:	AHD
PROJECTION:	55/2020
DATE OF PLAN:	7/13/2026
SCALE AT A1:	1:100
SHEET No.	09 OF 13
PLAN REF No.	26036-09
REV	B

TENDER

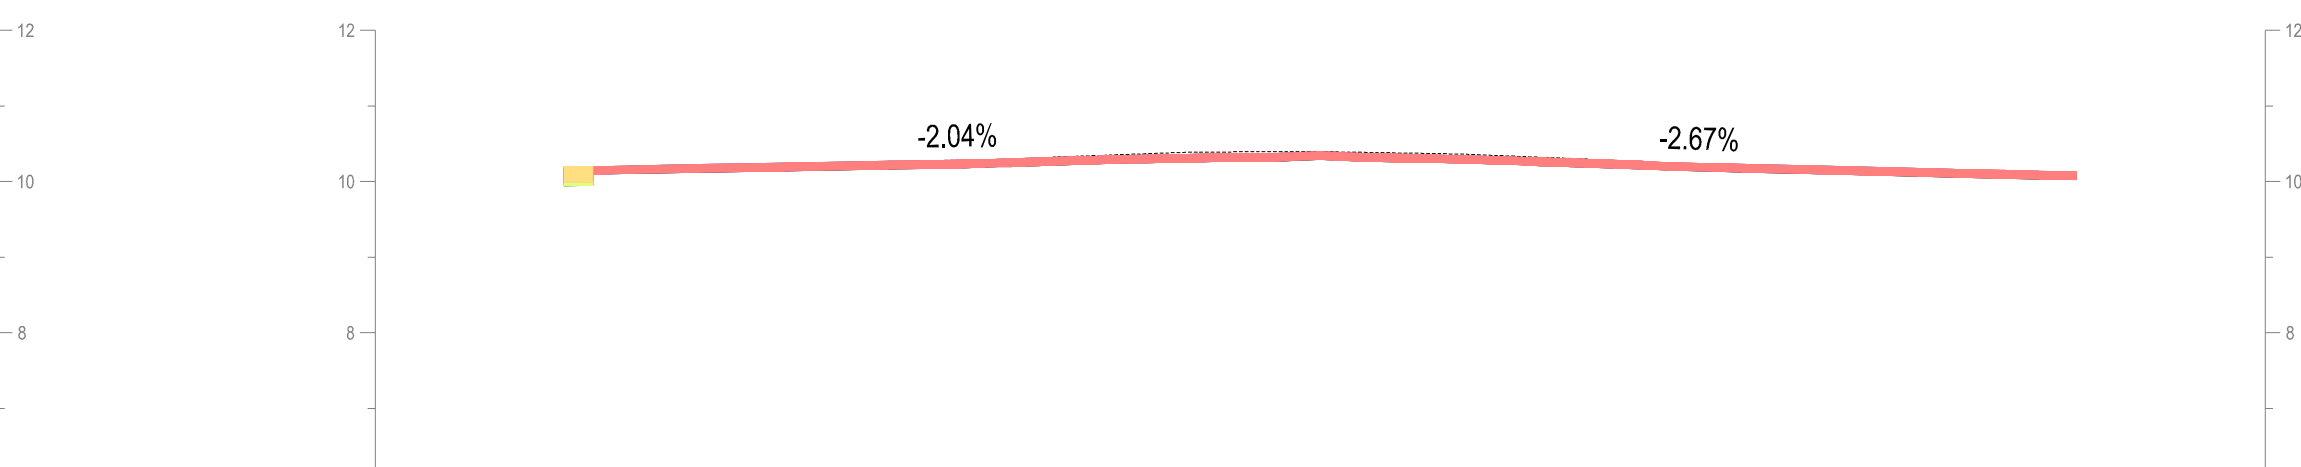


DESIGN	EXISTING	OFFSET
10.189	10.19	-10.000
10.200	10.20	-9.411
10.221	10.21	-8.301
10.243	10.23	-7.090
10.263	10.25	-6.165
10.277	10.28	-5.090
10.292	10.29	-4.367
10.314	10.30	-3.665
10.335	10.34	-2.934
10.352	10.37	-2.227
10.364	10.39	-1.519
10.369	10.39	-0.740
10.393	10.39	0.000
10.395	10.36	0.742
10.354	10.37	1.447
10.336	10.35	2.155
10.313	10.32	2.875
10.289	10.29	3.586
10.263	10.24	4.327
10.240	10.21	5.062
10.216	10.17	6.105
10.190	10.16	7.142
10.172	10.14	7.898
10.135	10.11	9.498
10.126	10.11	10.000

30.000

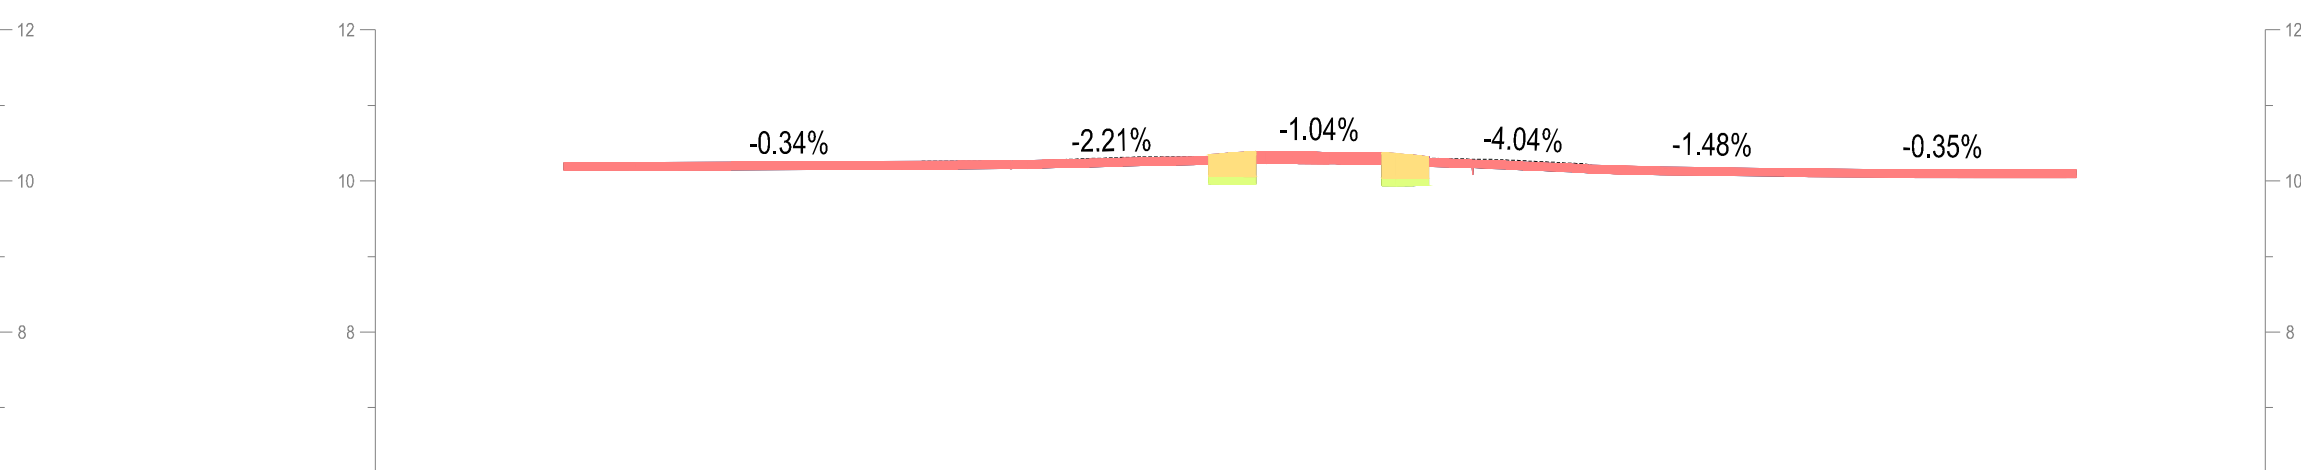[illegible]

25.000

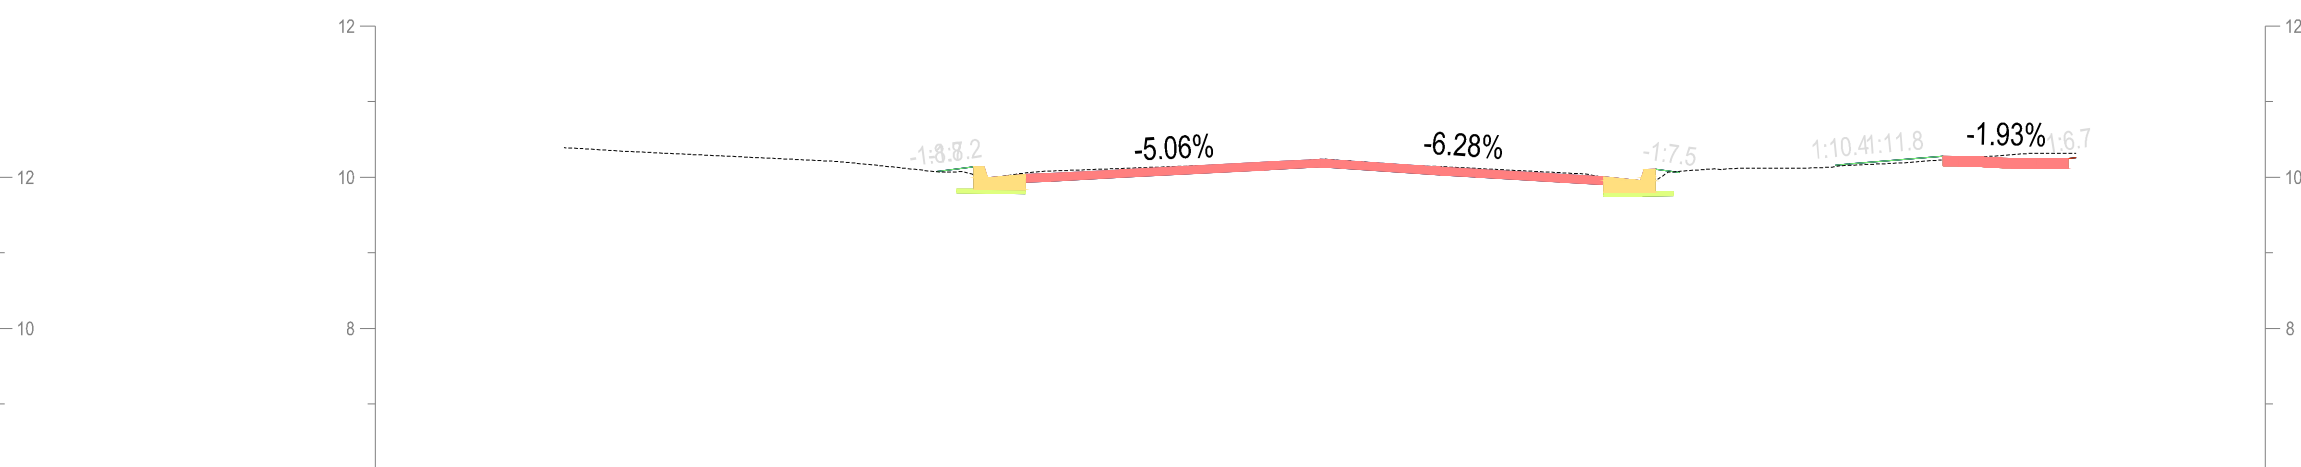
[illegible]

20.000


DATUM:	AHD
PROJECTION:	55:2020
DATE OF PLAN:	7/13/2026
SCALE AT A1 :	1:100
SHEET No. 10 OF 13	
PLAN REF No. 26036-10	REV B

TENDER


FILE PATH: K:\SIS\Design\PROJECTS\26036-11\Keogh Street & Potton Ave Roundabout2_TENDER.dwg
PLOT DATE: 13/07/2026

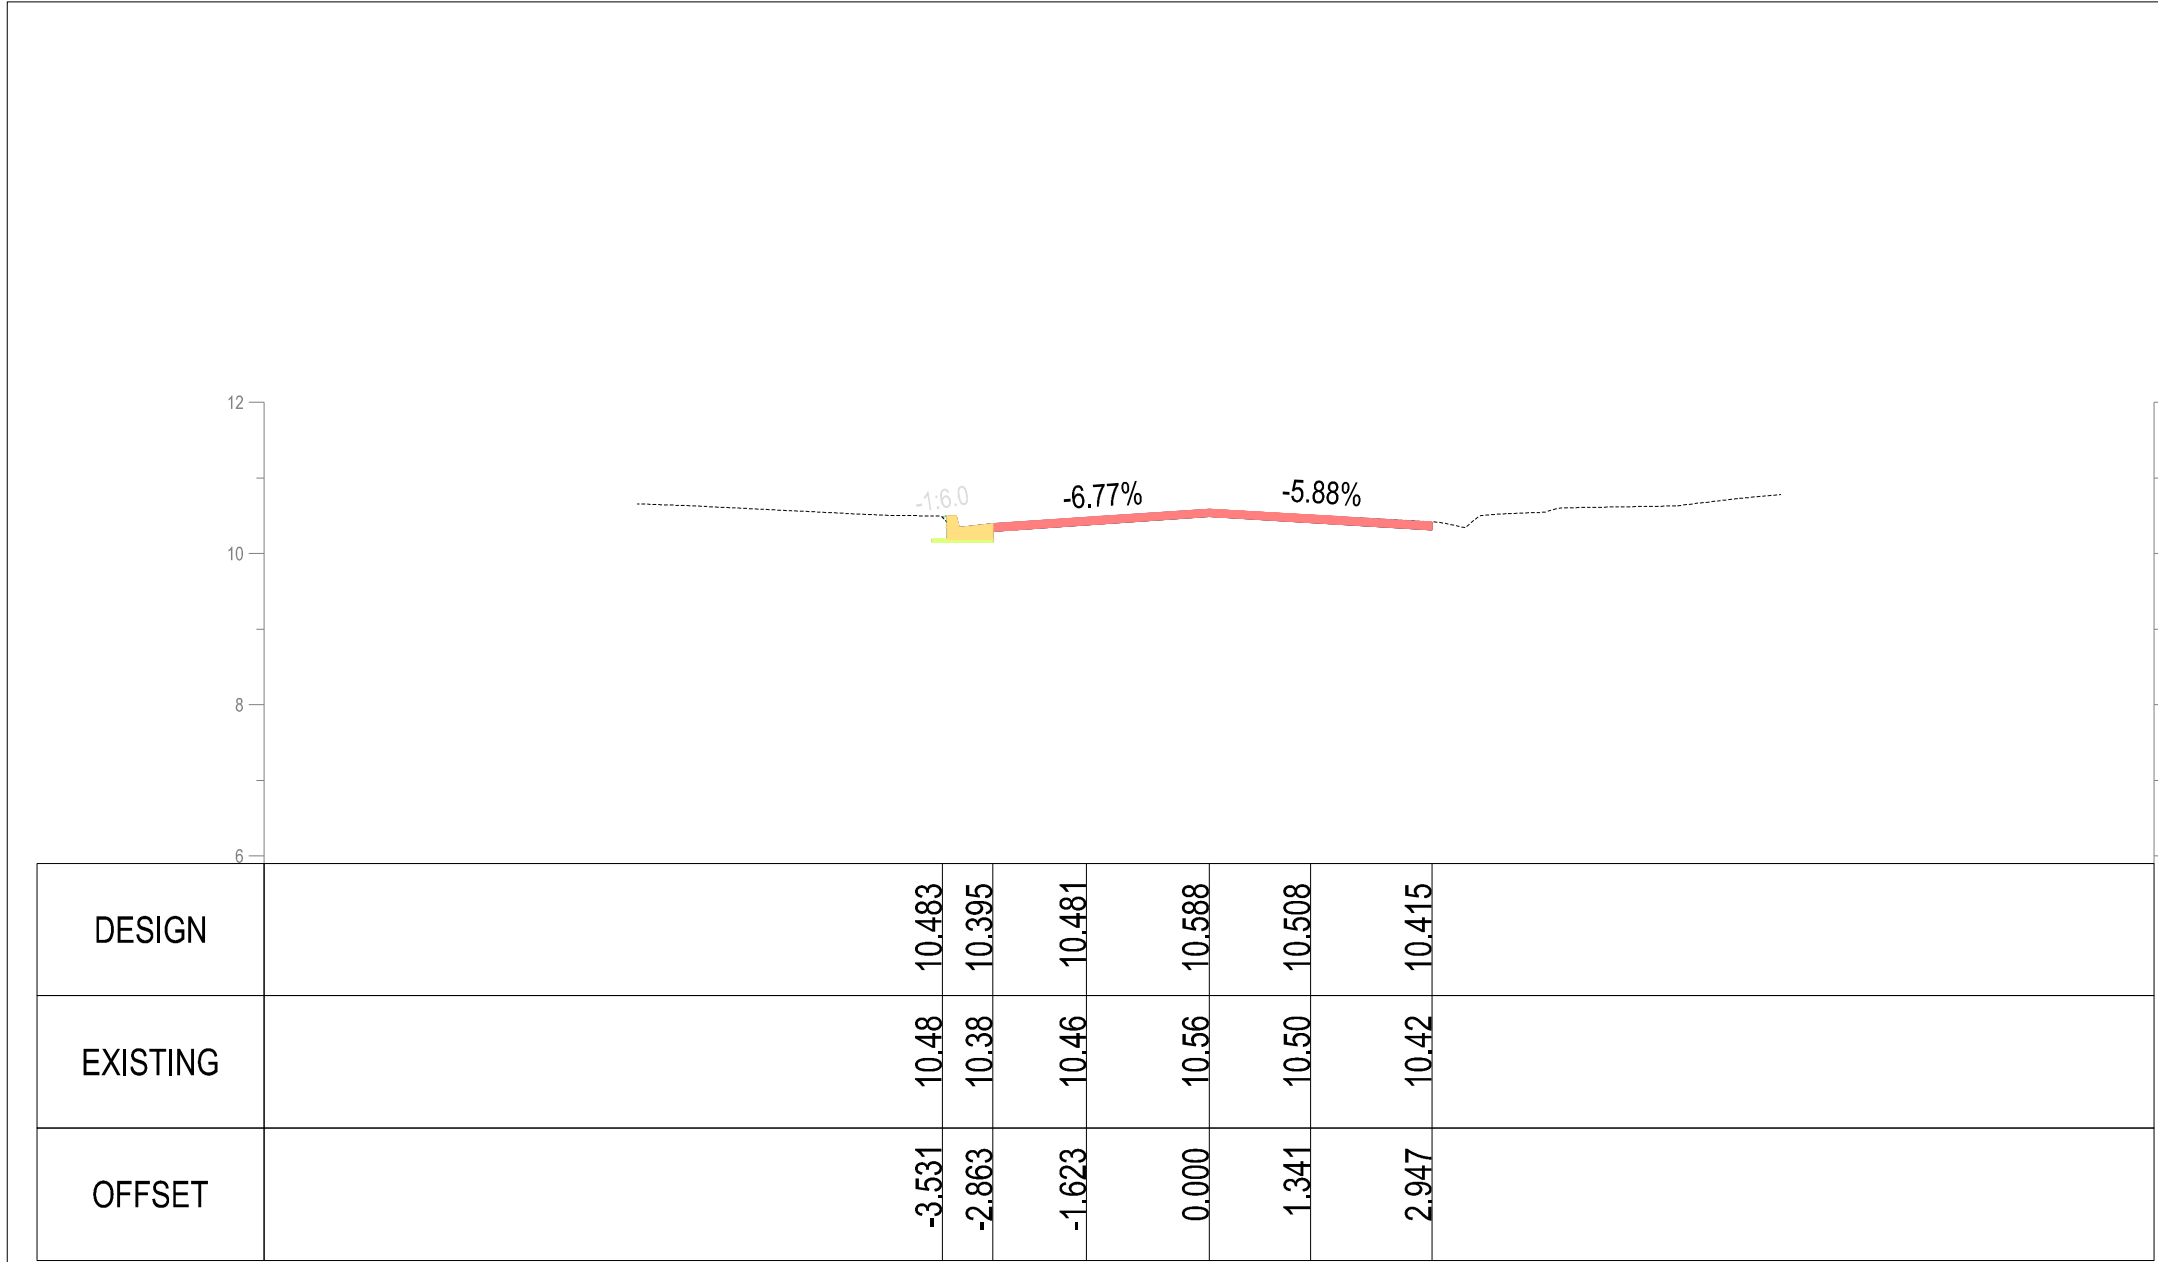


40.000

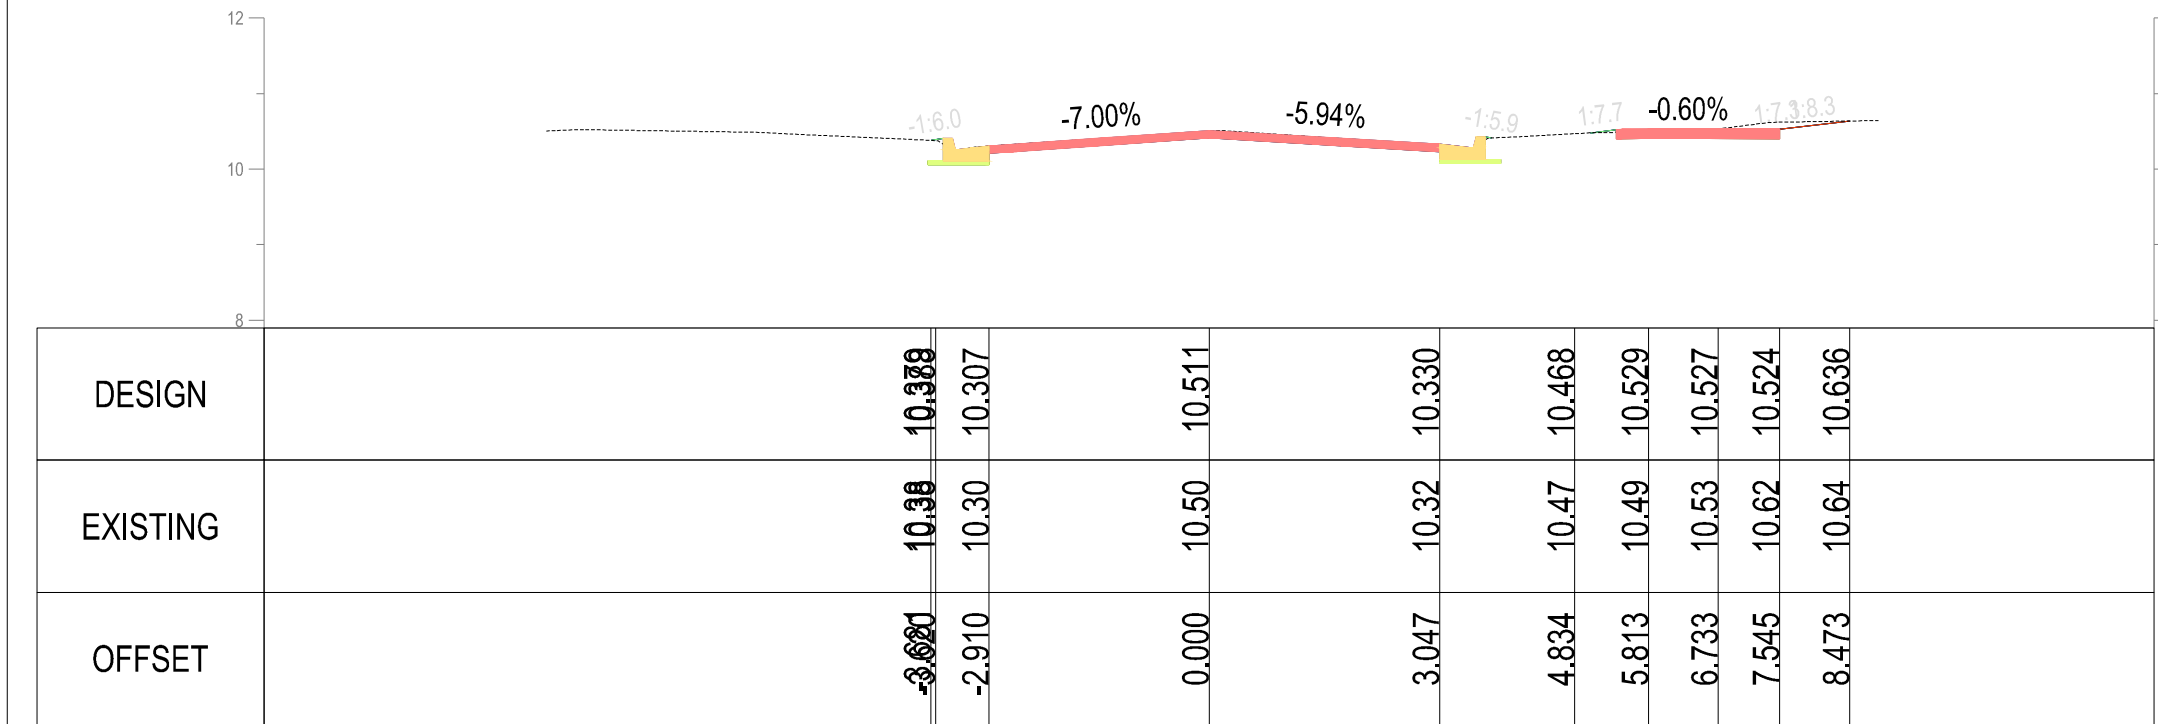


36.966

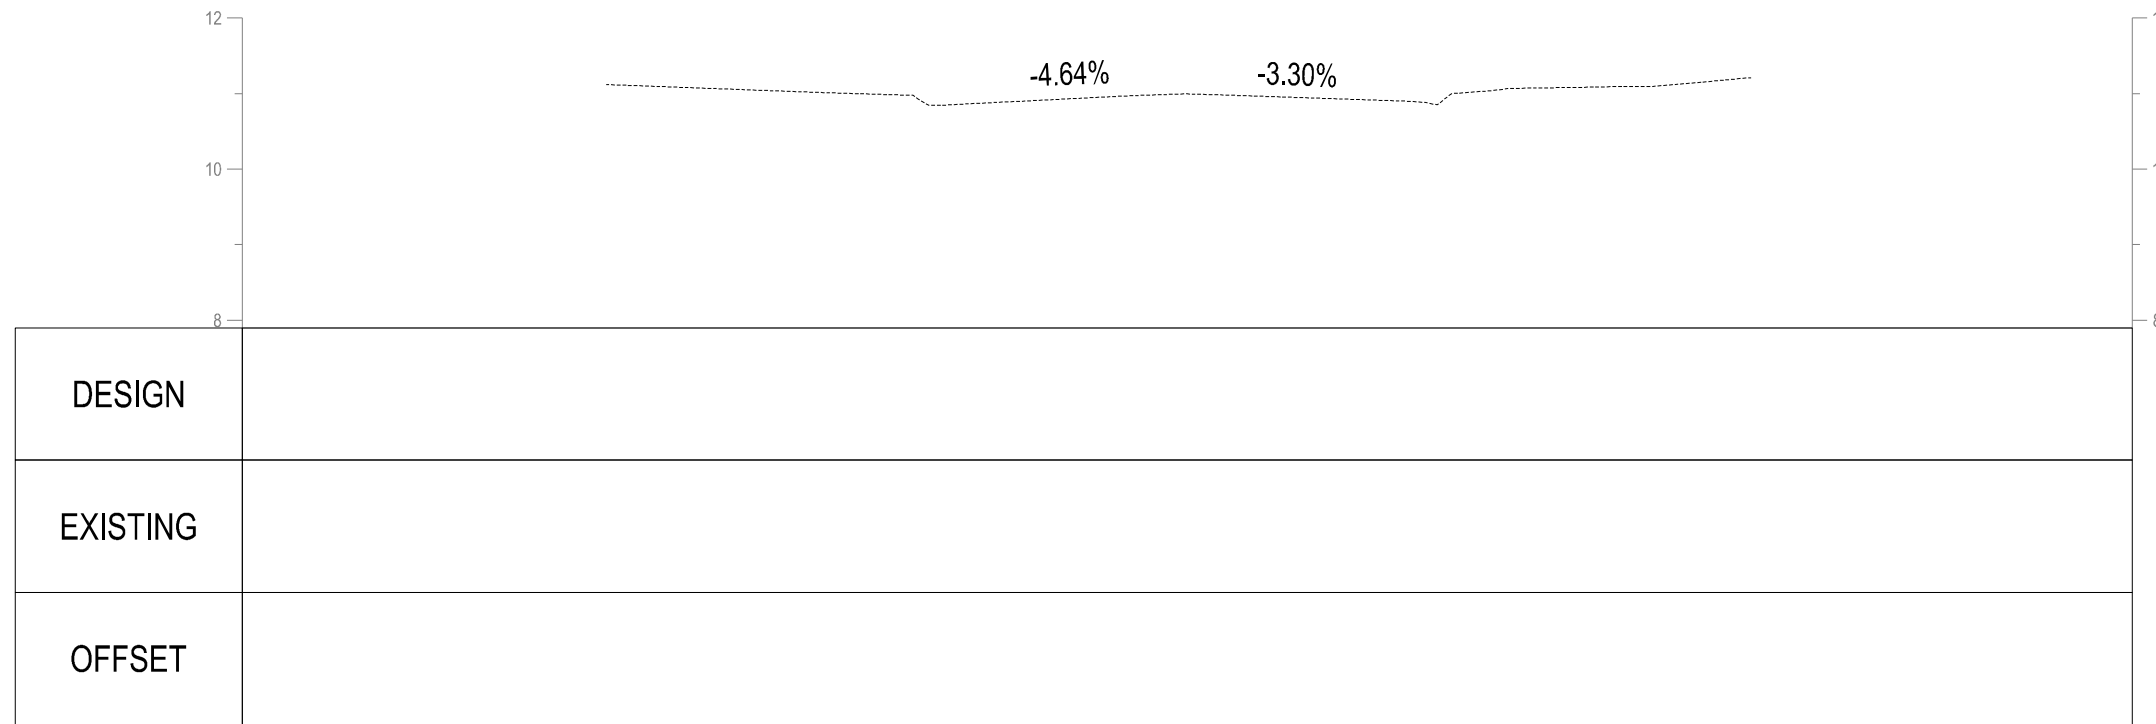

50.000

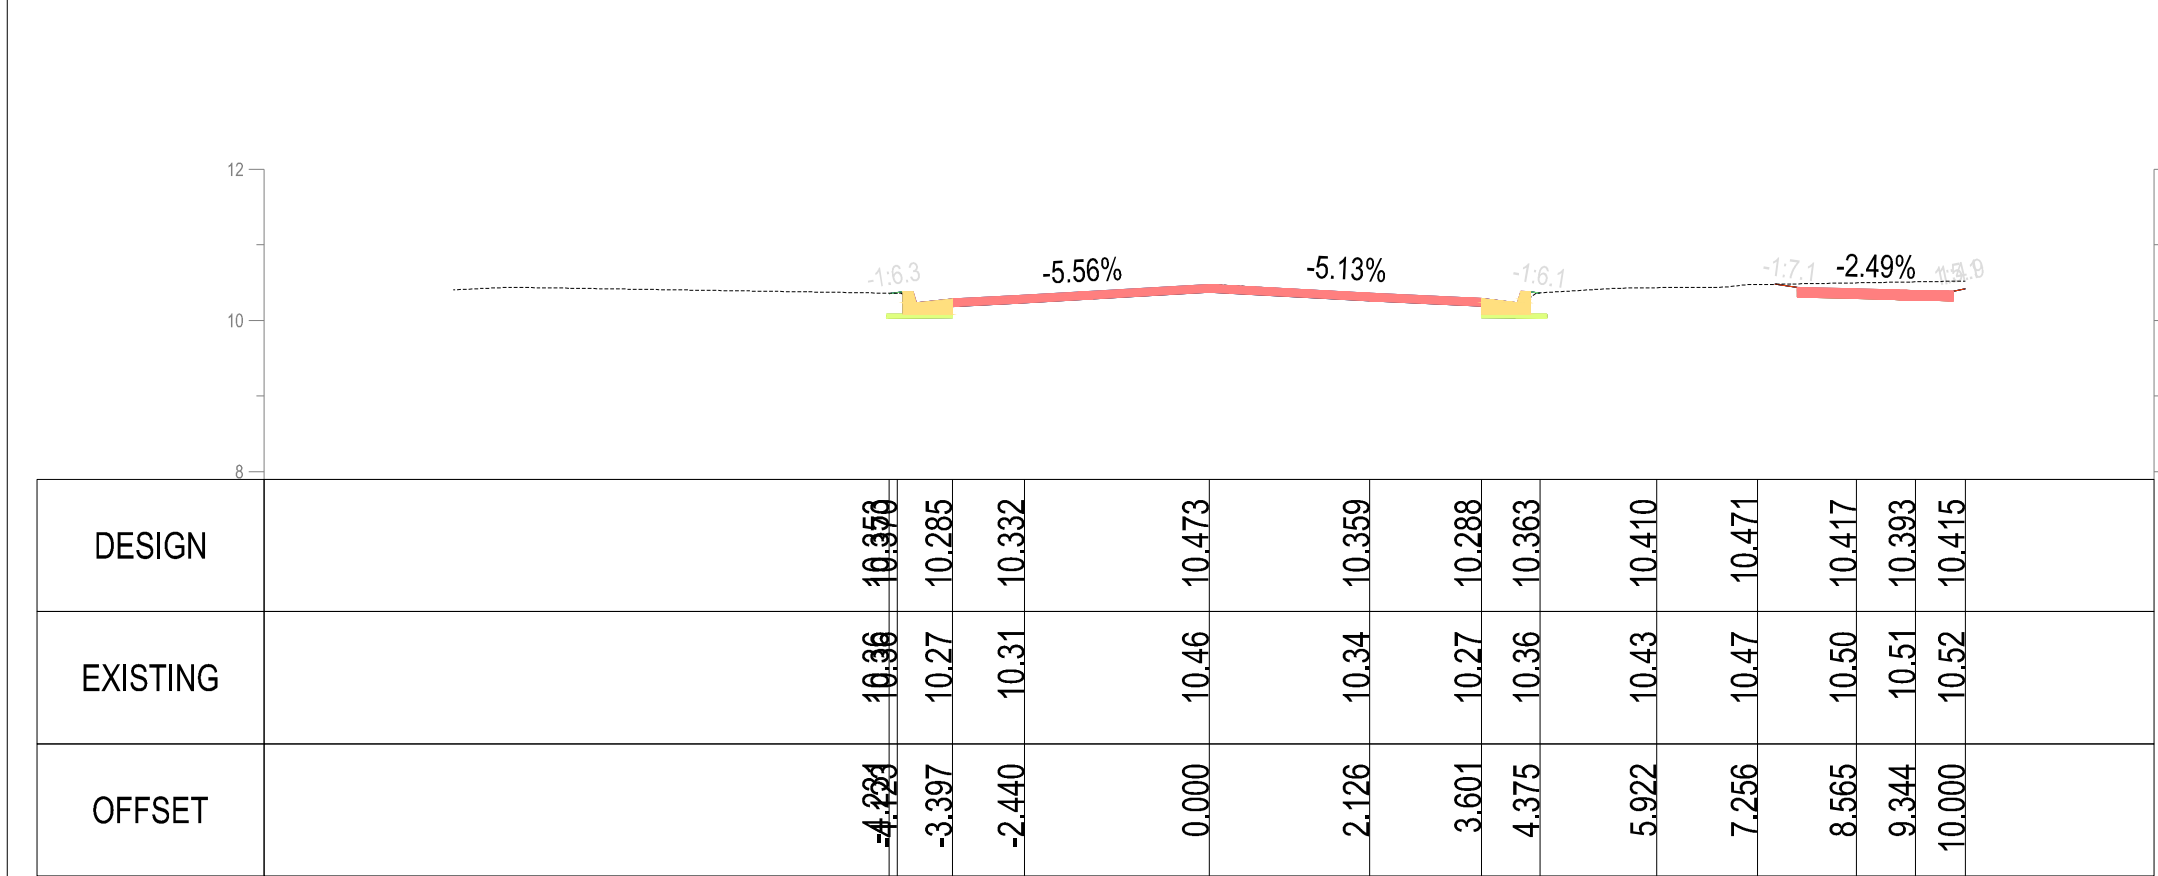

35.000

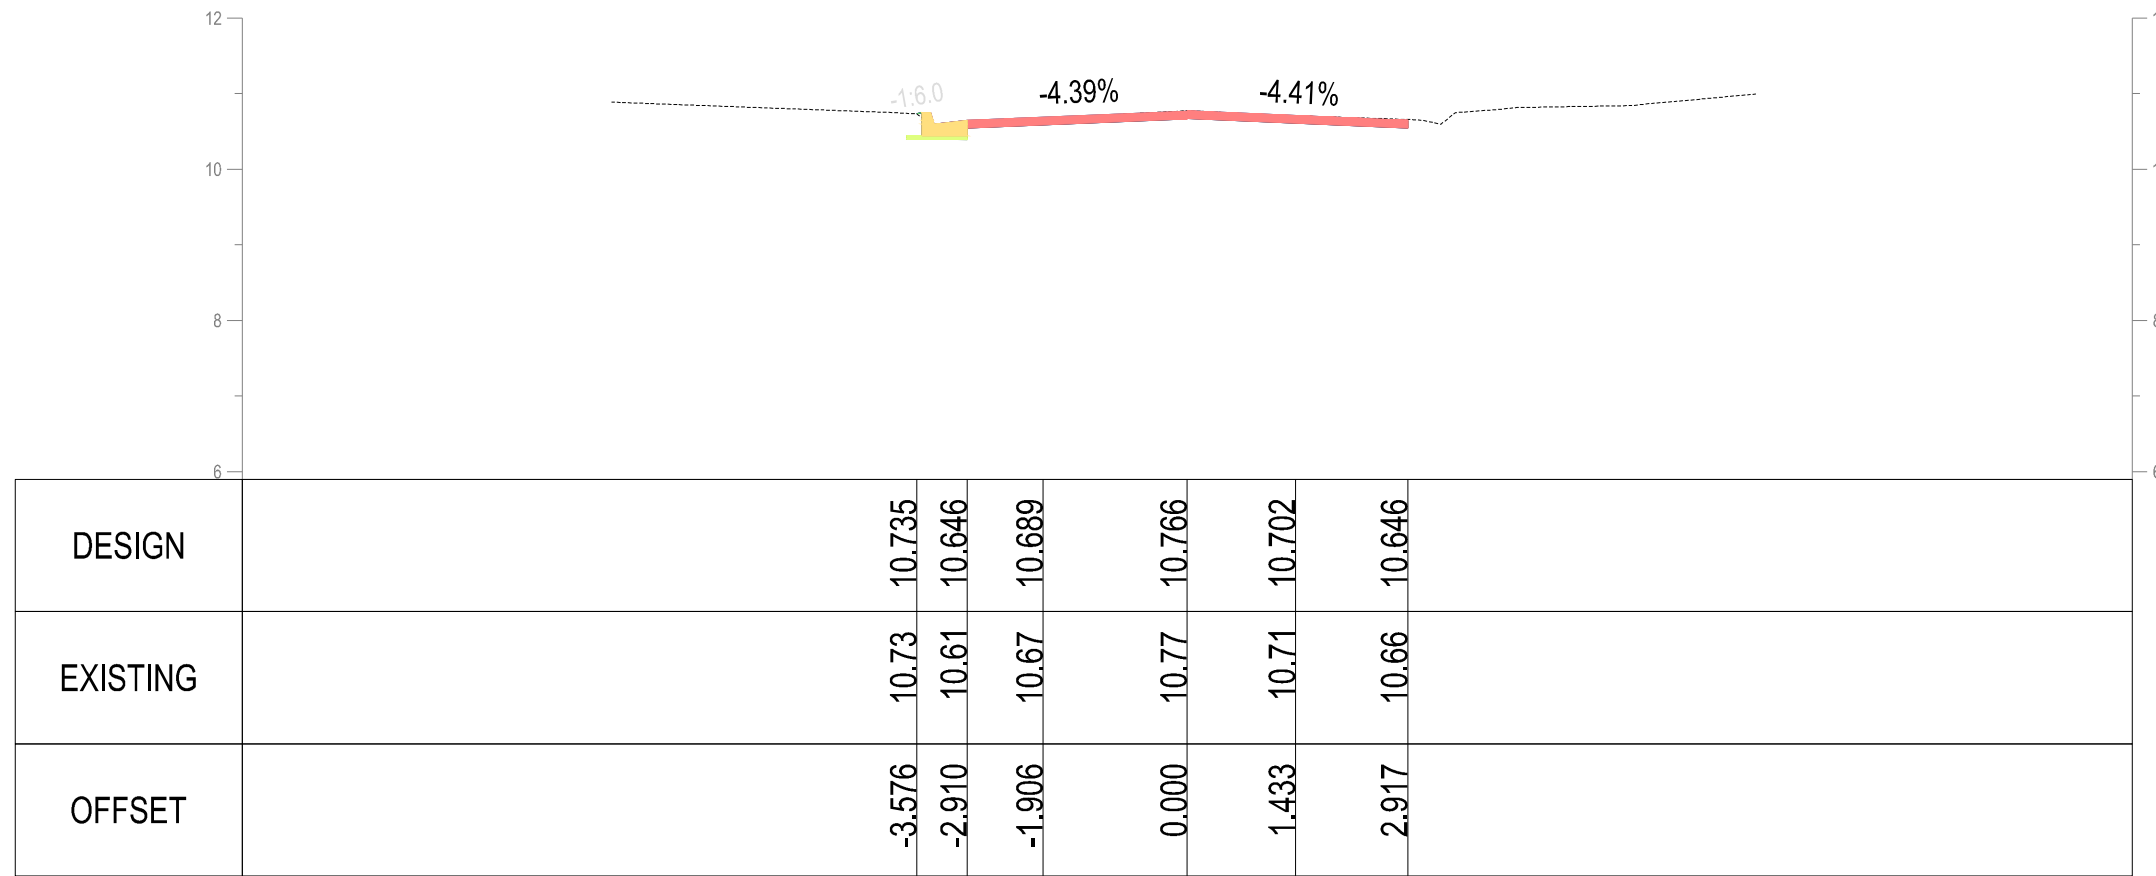

45.000

LEGEND									
	TELSTRA POLE		FIRE HYDRANT		EX UNDERGROUND ELECTRICITY CABLE		PROPOSED KERB AND CHANNEL		EXISTING HOUSE DRAIN
	TELSTRA PIT		WATER STOP VALVE		EX OVERHEAD POWER CABLE		EXISTING KERB AND CHANNEL		PROPOSED PROPERTY INLET
	PHONE BOX		GAS VALVE		PROPOSED WATER MAIN		TREE		
	POWER POLE		SEWER MANHOLE		PROPOSED GAS MAIN		TREE TO BE REMOVED		
	LIGHT POLE		EX WATER MAIN		PROPOSED U/G TELSTRA CABLE		PROPOSED DRAINAGE		
	LANTERN		EX GAS MAIN		PROPOSED SEWER MAIN		EXISTING DRAINAGE		
	UNDERGROUND POWER PIT		EX U/GROUND TELSTRA CABLE		PROPOSED U/G ELECTRICITY CABLE		PIT NUMBER		
	FIRE PLUG		EX SEWER MAIN		PERMANENT SURVEY MARK		PROPOSED HOUSE DRAIN		

REGISTERED ENGINEERS DETAILS	
NAME:	Michael Robins
SIGNATURE:	
ENG.REG.:	0008852
COMPANY:	Mornington Peninsula Shire







INTERNAL REFERENCES	
PROJECT QA:	26036
CONTRACT CN:	
CIVIL 3D DWG:	26036-11
SURVEY:	
DRAWN:	M. ROBINS
DESIGN:	M. ROBINS
CHECKED:	A. WAKILUZZAMAN
DATE:	13/07/26
DES:	MR
CHKD:	AW
APPD:	MR
DATE:	13/07/26



SAFE LOCAL ROADS AND STREET PROGRAM	
ROSEBUD	
KEOGH STREET & POTTON AVENUE	
ANNOTATED CROSS SECTIONS - MCK0 (2 OF 2)	
DATUM:	AHD
PROJECTION:	55/2020
DATE OF PLAN:	7/13/2026
SCALE AT A1 :	1:100
SHEET No. 11 OF 13	
PLAN REF No. 26036-11	REV B

TENDER

FILE PATH: K:\S:\Design\PROJECTS\26036-12\Keogh Street & Potton Ave Roundabout2_TENDER.dwg
PLOT DATE: 13/07/26
USER: A

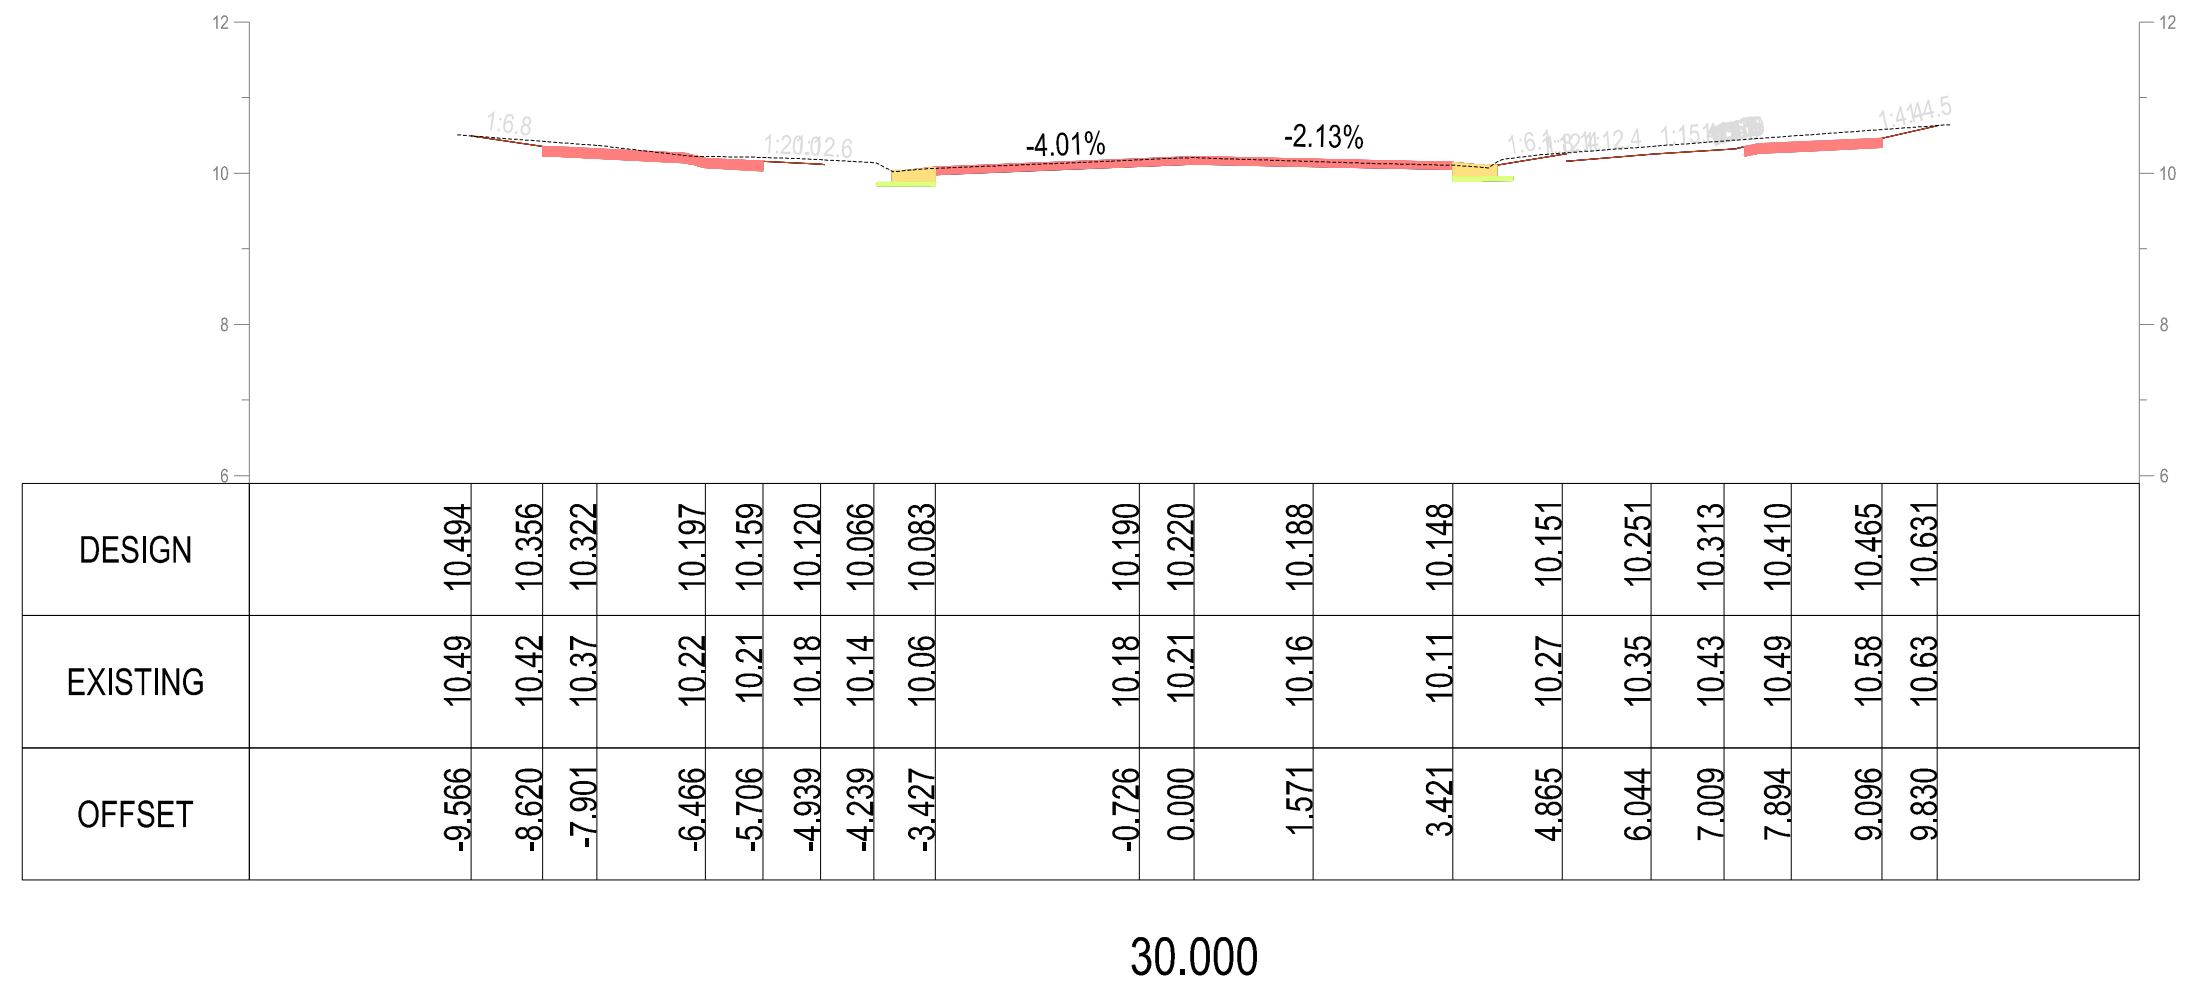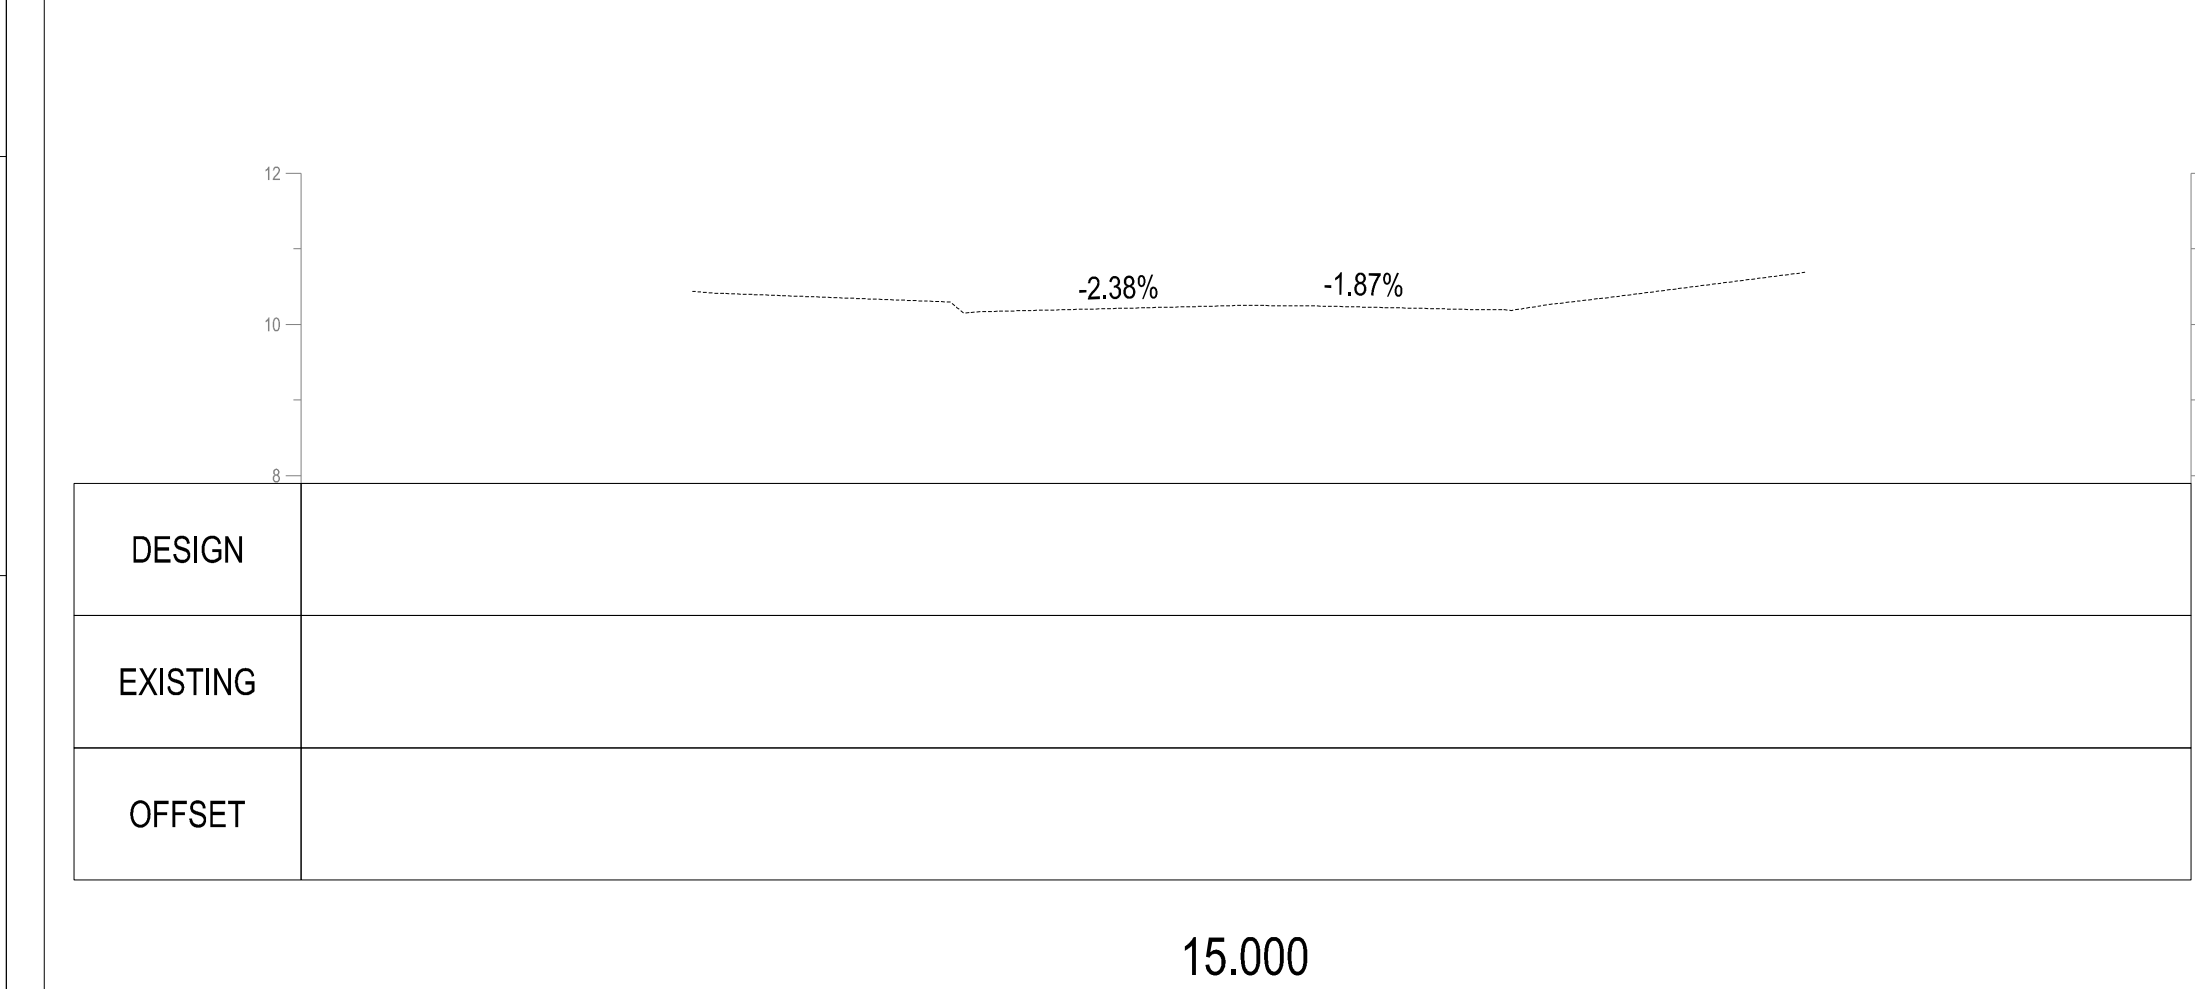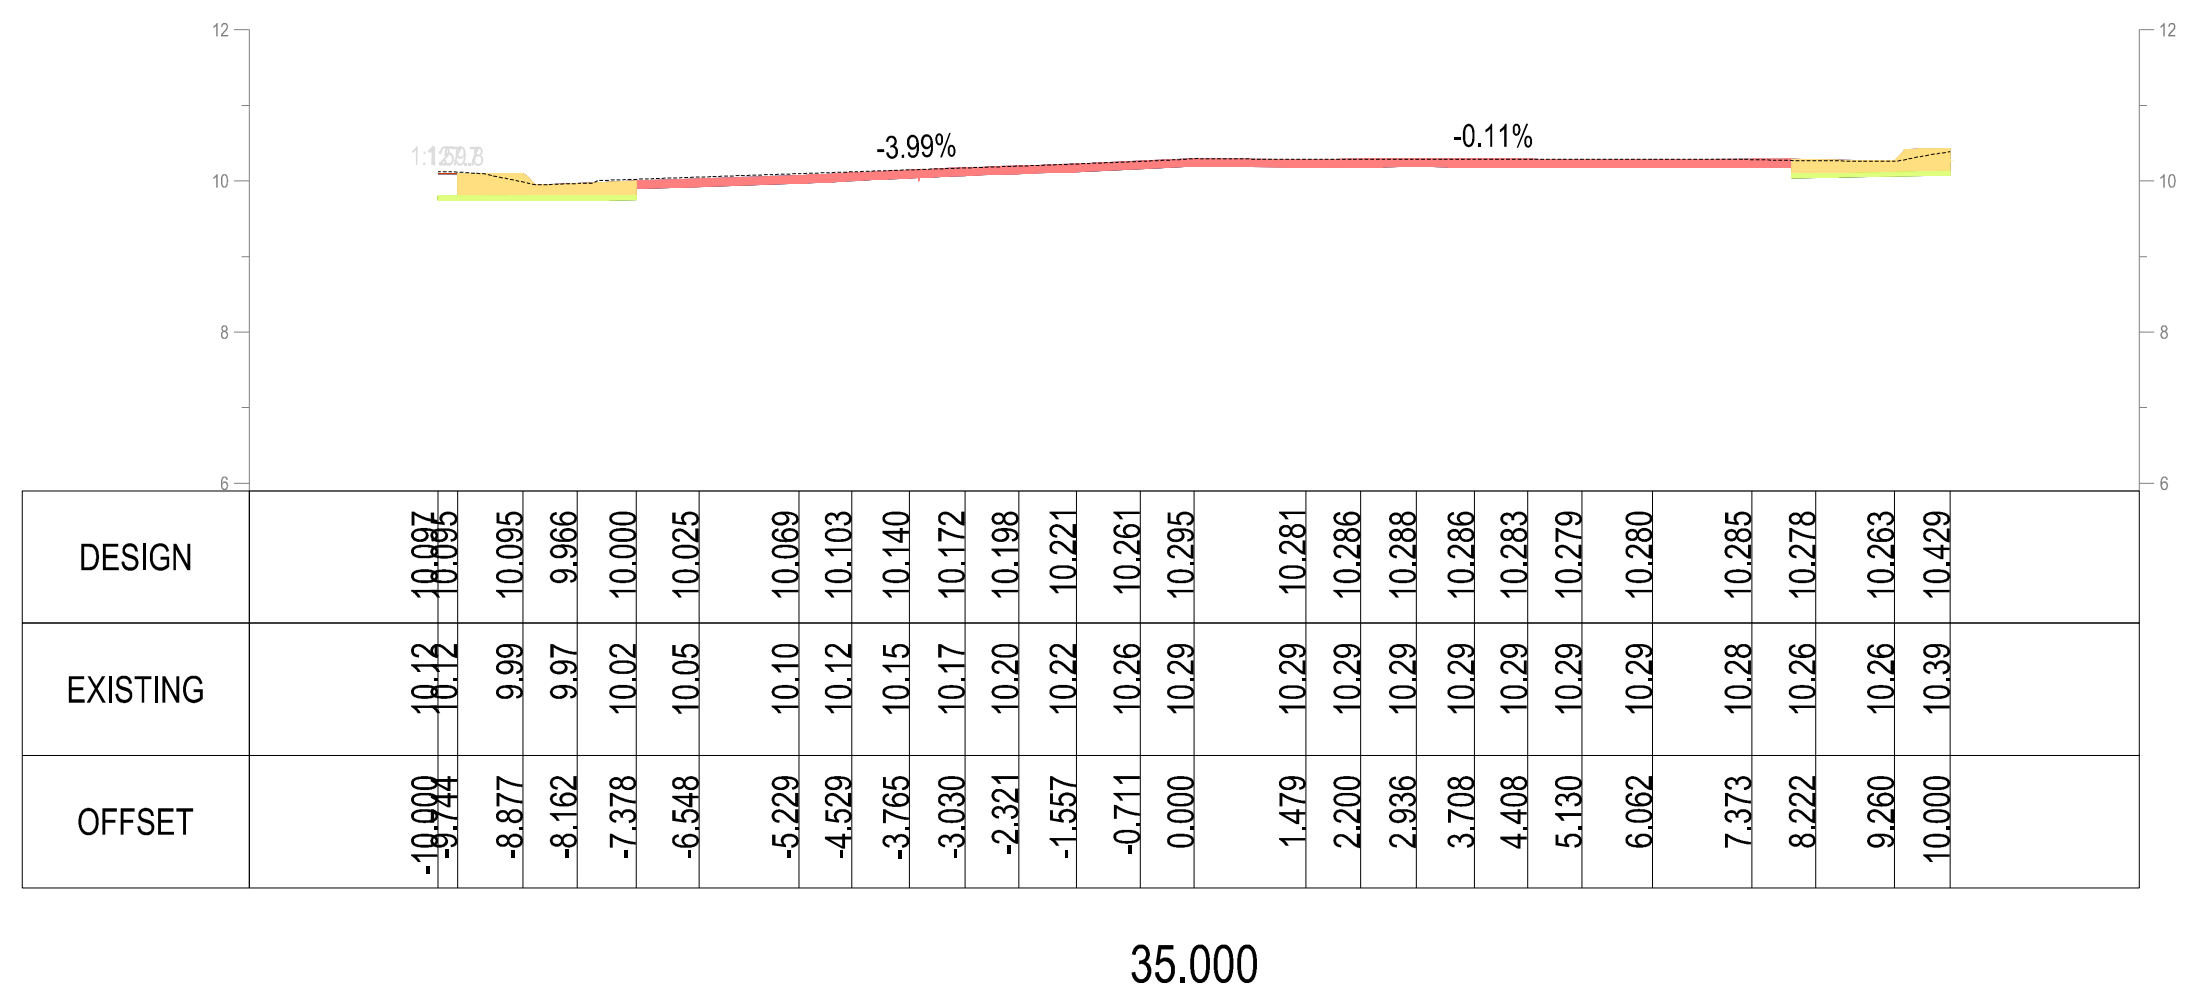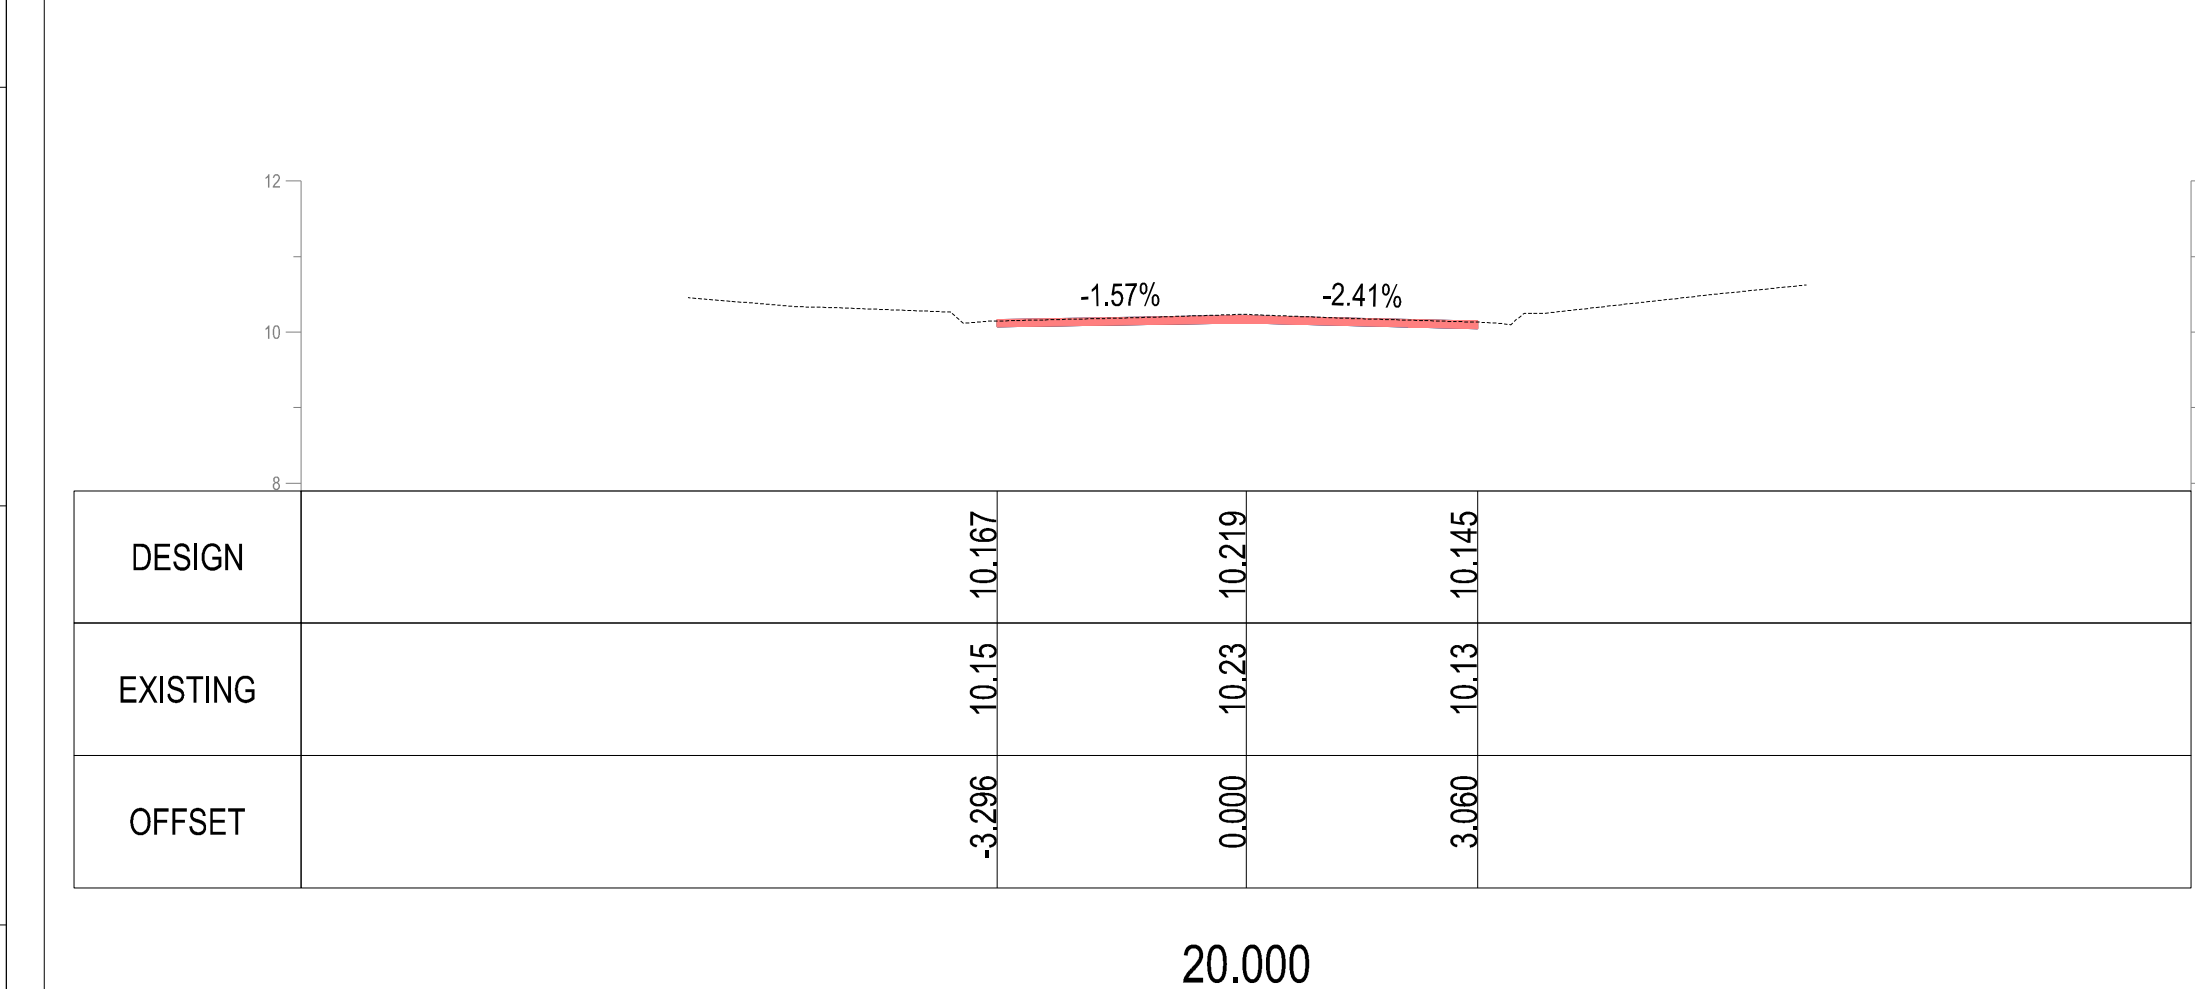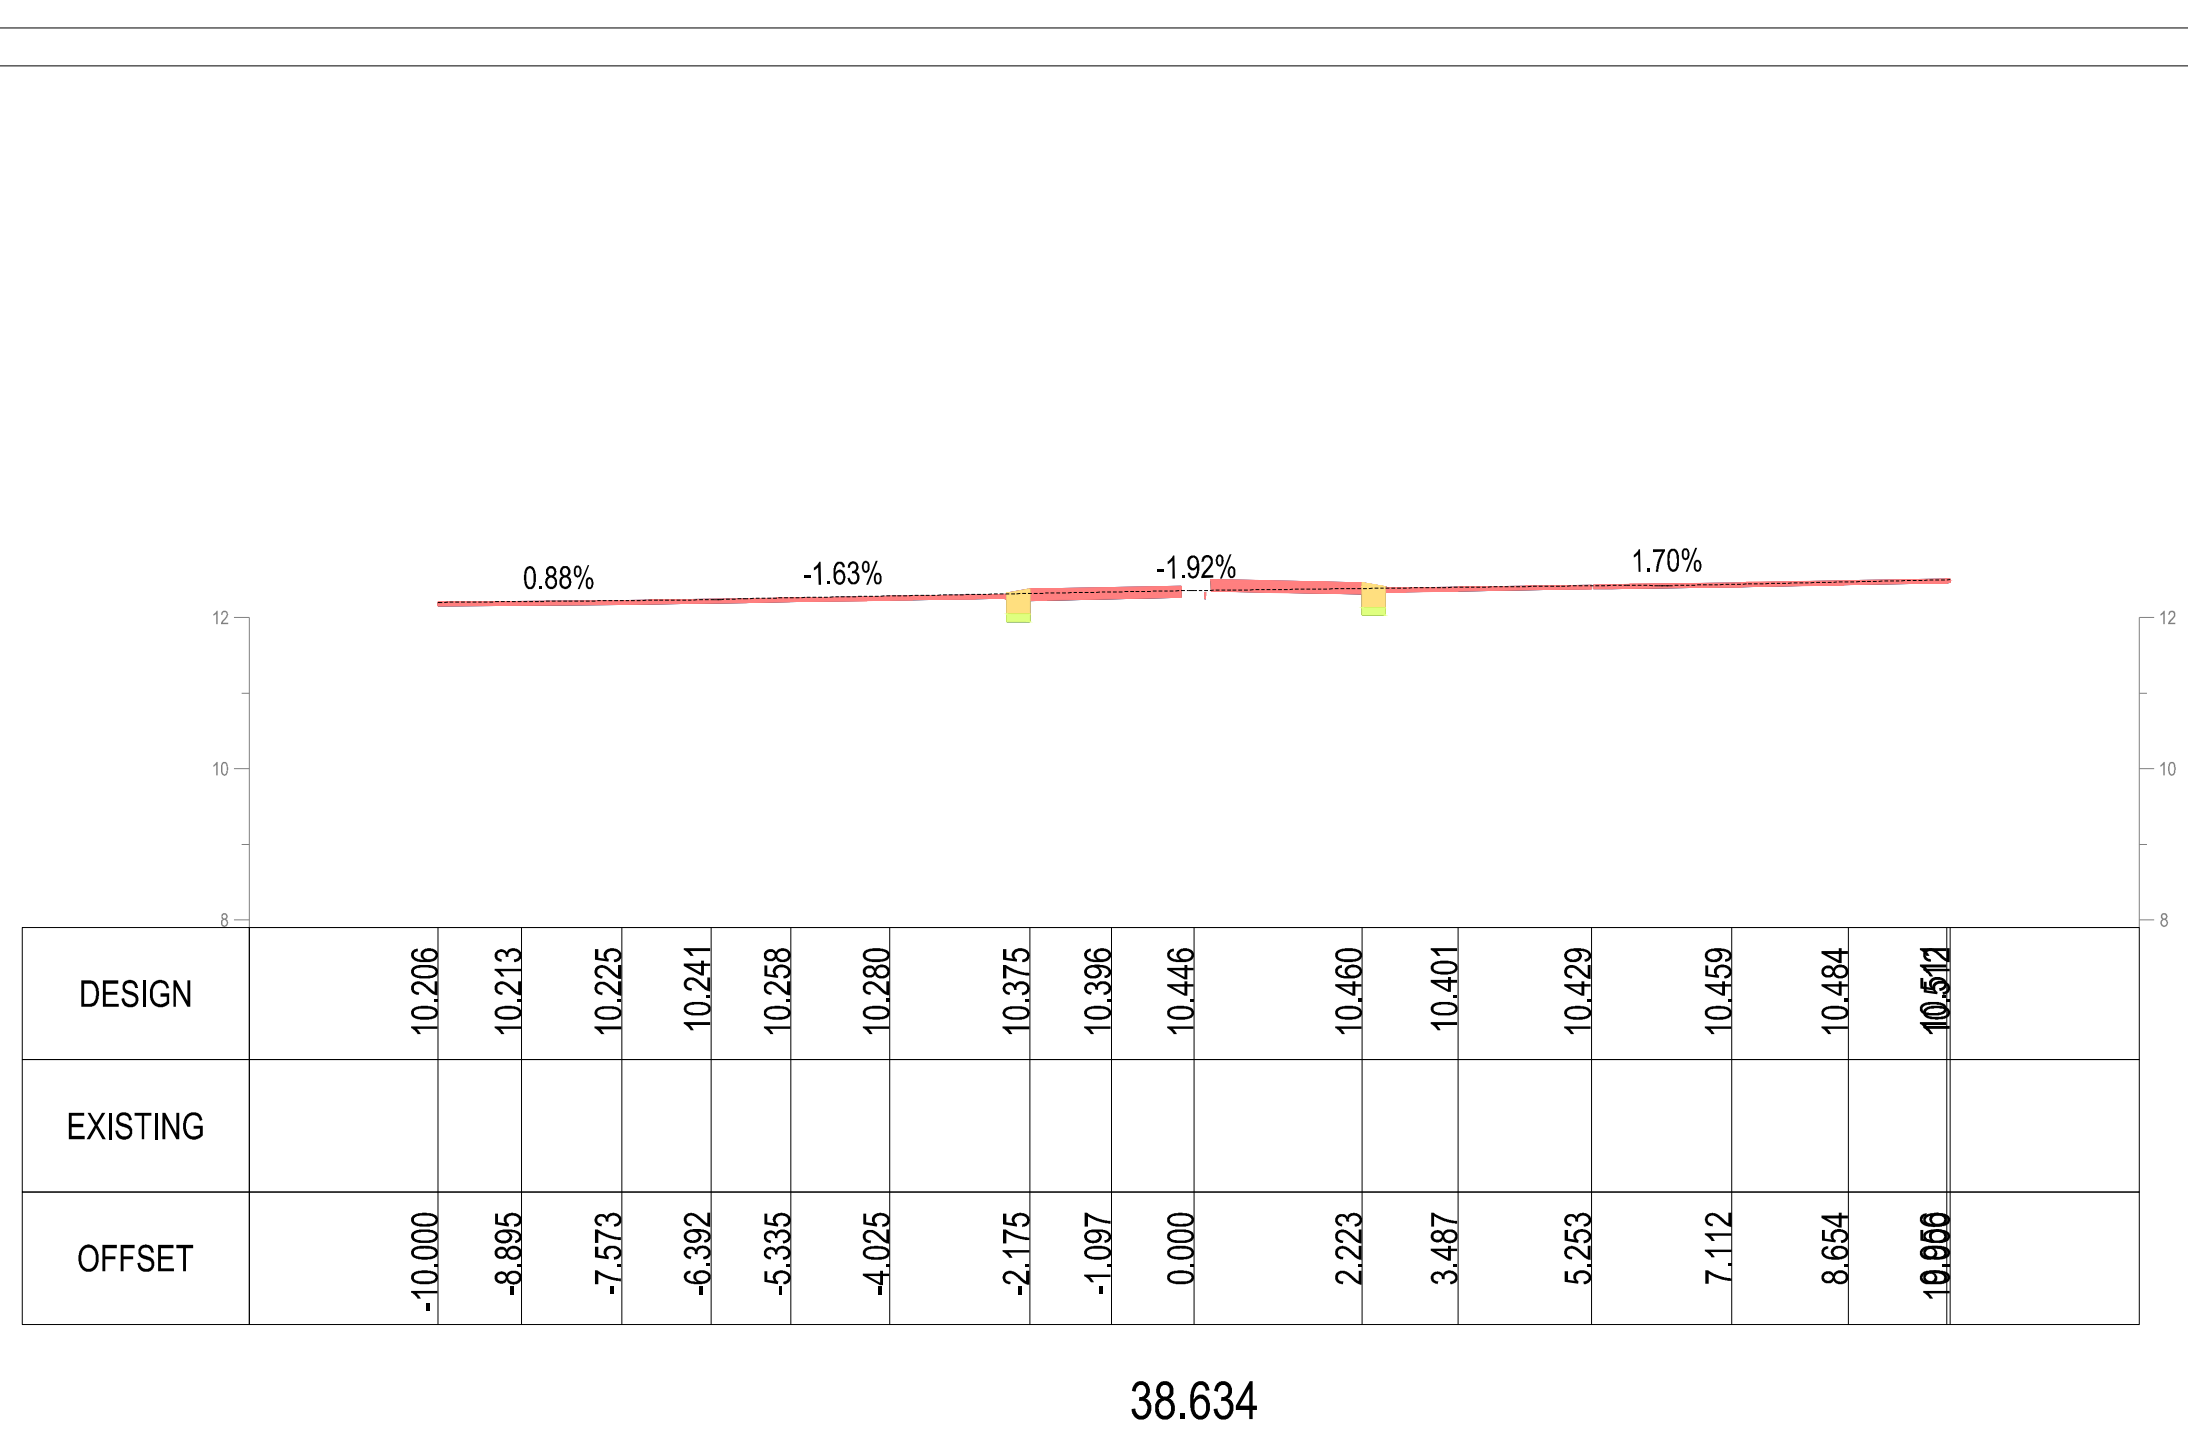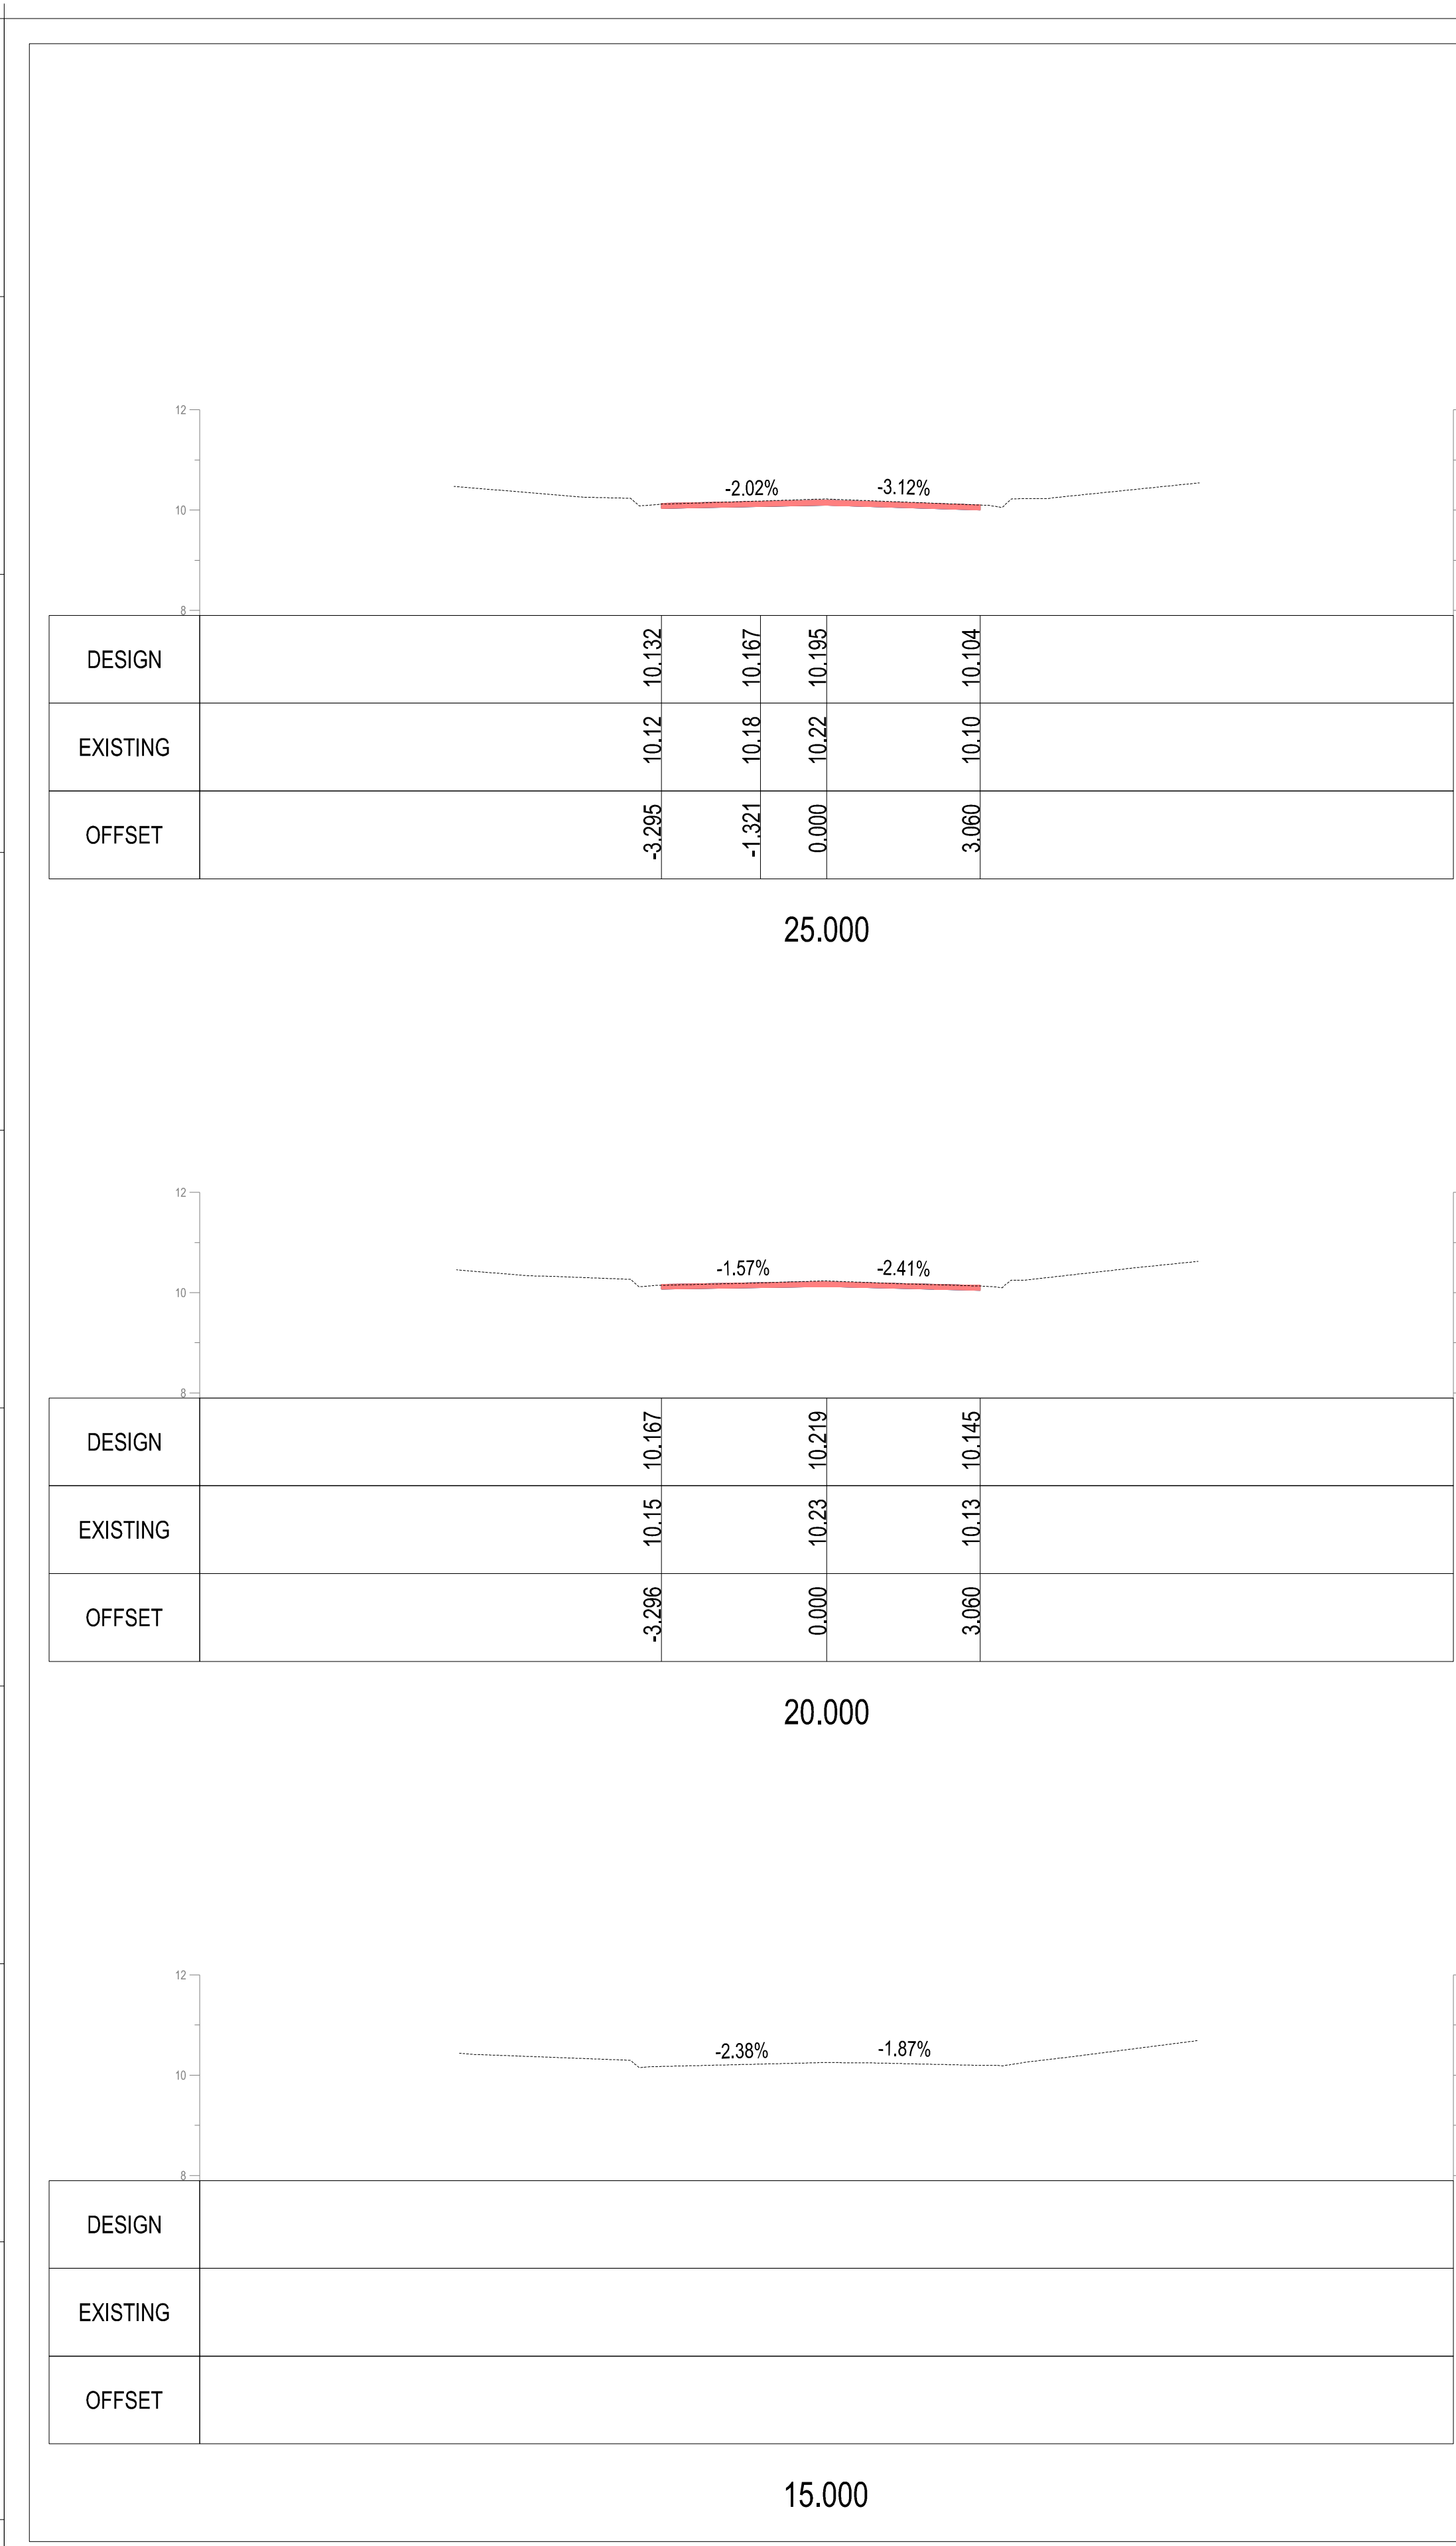

LEGEND									
	TELSTRA POLE		FIRE HYDRANT		EX U/GROUND ELECTRICITY CABLE		PROPOSED KERB AND CHANNEL		EXISTING HOUSE DRAIN
	TELSTRA PIT		WATER STOP VALVE		EX OVERHEAD POWER CABLE		EXISTING KERB AND CHANNEL		PROPOSED PROPERTY INLET
	PHONE BOX		GAS VALVE		PROPOSED WATER MAIN		TREE		
	POWER POLE		SEWER MANHOLE		PROPOSED GAS MAIN		TREE TO BE REMOVED		
	LIGHT POLE		EX WATER MAIN		PROPOSED U/G TELSTRA CABLE		PROPOSED DRAINAGE		
	LANTERN		EX GAS MAIN		PROPOSED SEWER MAIN		EXISTING DRAINAGE		
	UNDERGROUND POWER PIT		EX U/GROUND TELSTRA CABLE		PROPOSED U/G ELECTRICITY CABLE		PIT NUMBER		
	FIRE PLUG		EX SEWER MAIN		PERMANENT SURVEY MARK		PROPOSED HOUSE DRAIN		

REGISTERED ENGINEERS DETAILS	
NAME:	Michael Robins
SIGNATURE:	
ENG. REG.:	0008852
COMPANY:	Mornington Peninsula Shire

INTERNAL REFERENCES				
PROJECT QA:	26036			
CONTRACT CN:	26036-12			
CIVIL 3D DWG:				
SURVEY:				
DRAWN:	M. ROBINS			
DESIGN:	M. ROBINS			
CHECKED:	A. WAKILUZZAMAN			
B	TENDER ISSUE	MR	AW	MR
A	ISSUED FOR REVIEW			
No	DRAWING REVISION DETAILS	DES	CHKD	APPD
				DATE

13/07/26



SAFE LOCAL ROADS AND STREET PROGRAM	
ROSEBUD	
KEOGH STREET & POTTON AVENUE	
ANNOTATED CROSS SECTIONS - MCP0 (1 OF 2)	


DATUM:	AHD
PROJECTION:	55/2020
DATE OF PLAN:	7/13/2026
SCALE AT A1 :	1:100
SHEET No. 12 OF 13	
PLAN REF No.	REV
26036-12	B

TENDER

DESIGN	
EXISTING	
OFFSET	

65.000

	-8

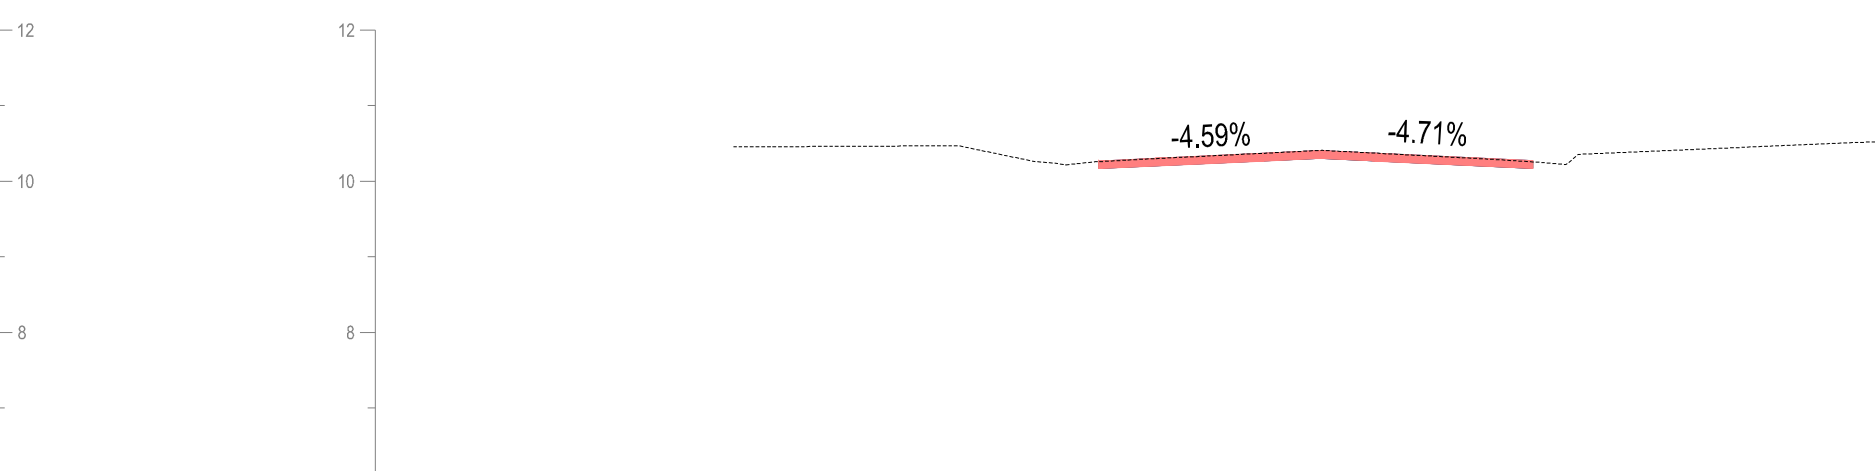

The chart displays the change in the number of employees in the manufacturing sector from 2010 to 2019. The y-axis represents the percentage change, ranging from -8 to 12. The x-axis represents the years. A red line indicates the annual percentage change, with specific values for 2018 (-4.59%) and 2019 (-4.71%) highlighted. A dotted line shows the overall trend, which remains relatively flat around 10%.

Year	Change in Number of Employees (%)
2010	10.5
2011	10.5
2012	10.5
2013	10.5
2014	10.5
2015	10.5
2016	10.5
2017	10.5
2018	-4.59
2019	-4.71


60,000

ENDER

REGISTERED ENGINEERS DETAILS	
NAME:	Michael Robins
SIGNATURE:	
ENG.REG.:	0008852
COMPANY:	Mornington Peninsula Shire

B	TENDER ISSUE
A	ISSUED FOR REVIEW
No	DRAWING REVISION DETAILS

				INTERNAL REFERENCES	
				PROJECT QA:	26036
				CONTRACT CN:	
				CIVIL 3D DWG:	26036-13
				SURVEY:	
MR	AW	MR	13/07/26	DRAWN:	M. ROBINS
				DESIGN:	M. ROBINS
DES	CHKD	APPD	DATE	CHECKED:	A. WAKILUZZAMAN

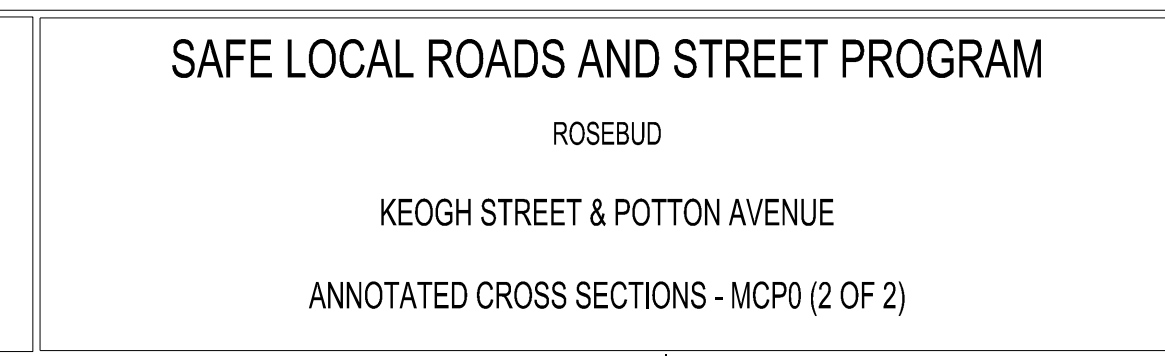10